




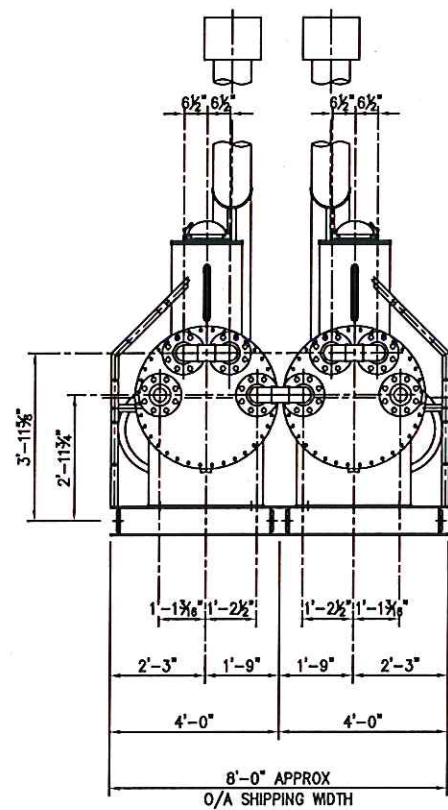

COIL END VIEW

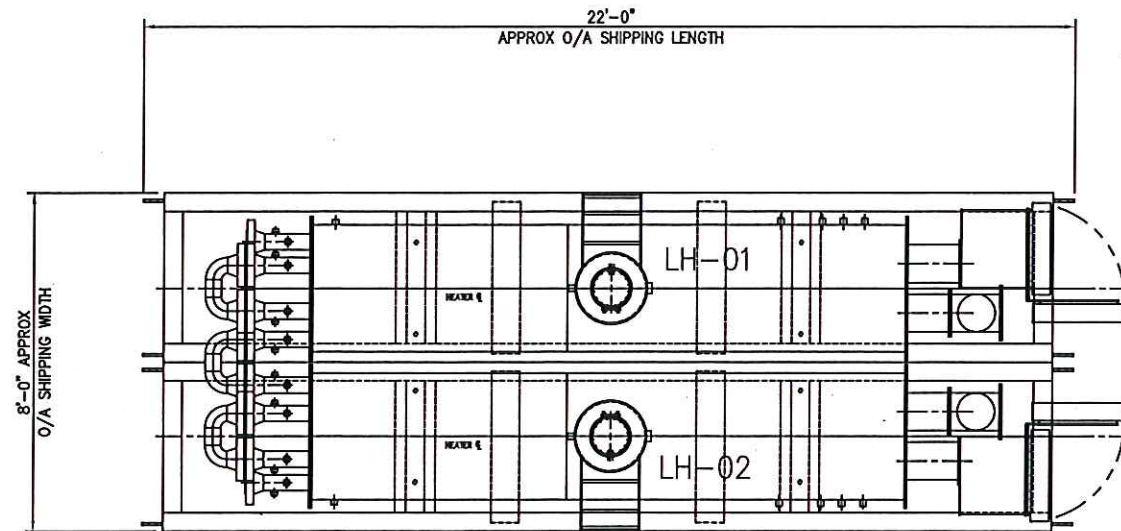

PLAN VIEW

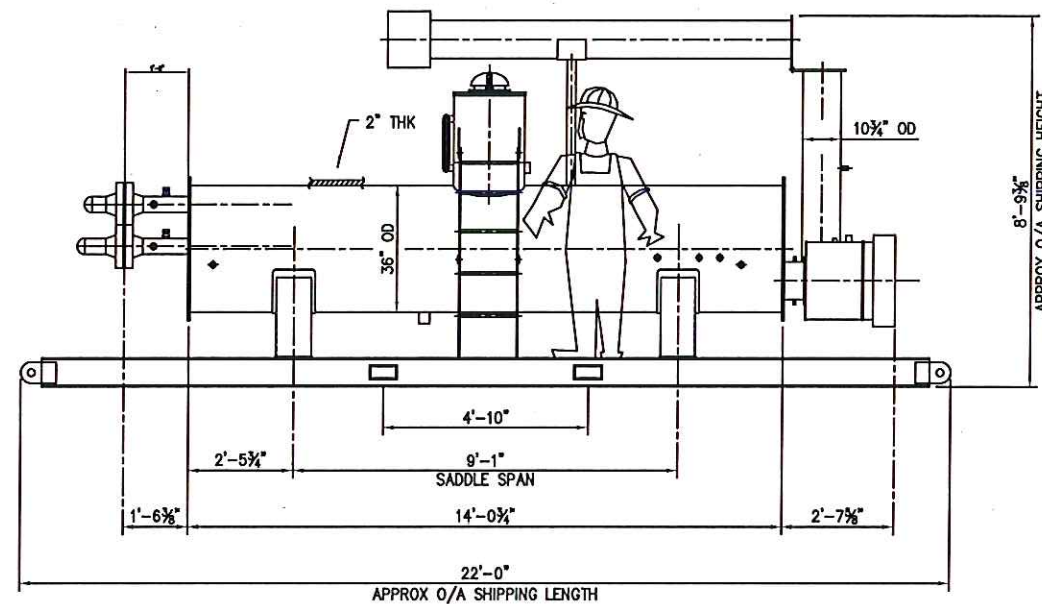

SIDE VIEW

AS BUILT

GENERAL NOTES:

- 1) FOR EQUIPMENT AND INSTRUMENTATION DESCRIPTIONS REFER TO PROJECT DATA LIST.
- 2) TOTAL APPROX. SHIPPING WEIGHT: 14000 lbs
- 3) APPROX. SHELL VOLUME: 560 usgal. EA
- 4) TOTAL APPROX. OPERATING WEIGHT: 18000 lbs

ENERGERA

PO# 23258

SO# 231054

THIS DRAWING IS THE PROPERTY OF FOURSTAR RESOURCES INC. AND IS NOT TO BE PRINTED, PHOTOGRAPHED, COPIED, LOANED OR USED WITHOUT ITS PERMISSION

REV.	DESCRIPTION	BY	CHK'D	DATE
0	ISSUED FOR CONSTRUCTION	WT	WT	AUG23/23
B	RE-ISSUED FOR APPROVAL	WT	WT	AUG02/23







FSR
INC

FOURSTAR RESOURCES INC.
NISKU, ALBERTA, CANADA

DRAWN BY:	DATE	CHECKED BY:	DATE
WT	JAN11/21	WT	JAN11/21
APPROVED BY:	DATE	SCALE:	
WT	JAN11/21	AS SHOWN	

DUAL FSR750IH
INDIRECT HEATER
GENERAL ARRANGEMENT

DRAWING NO.
231054 GA

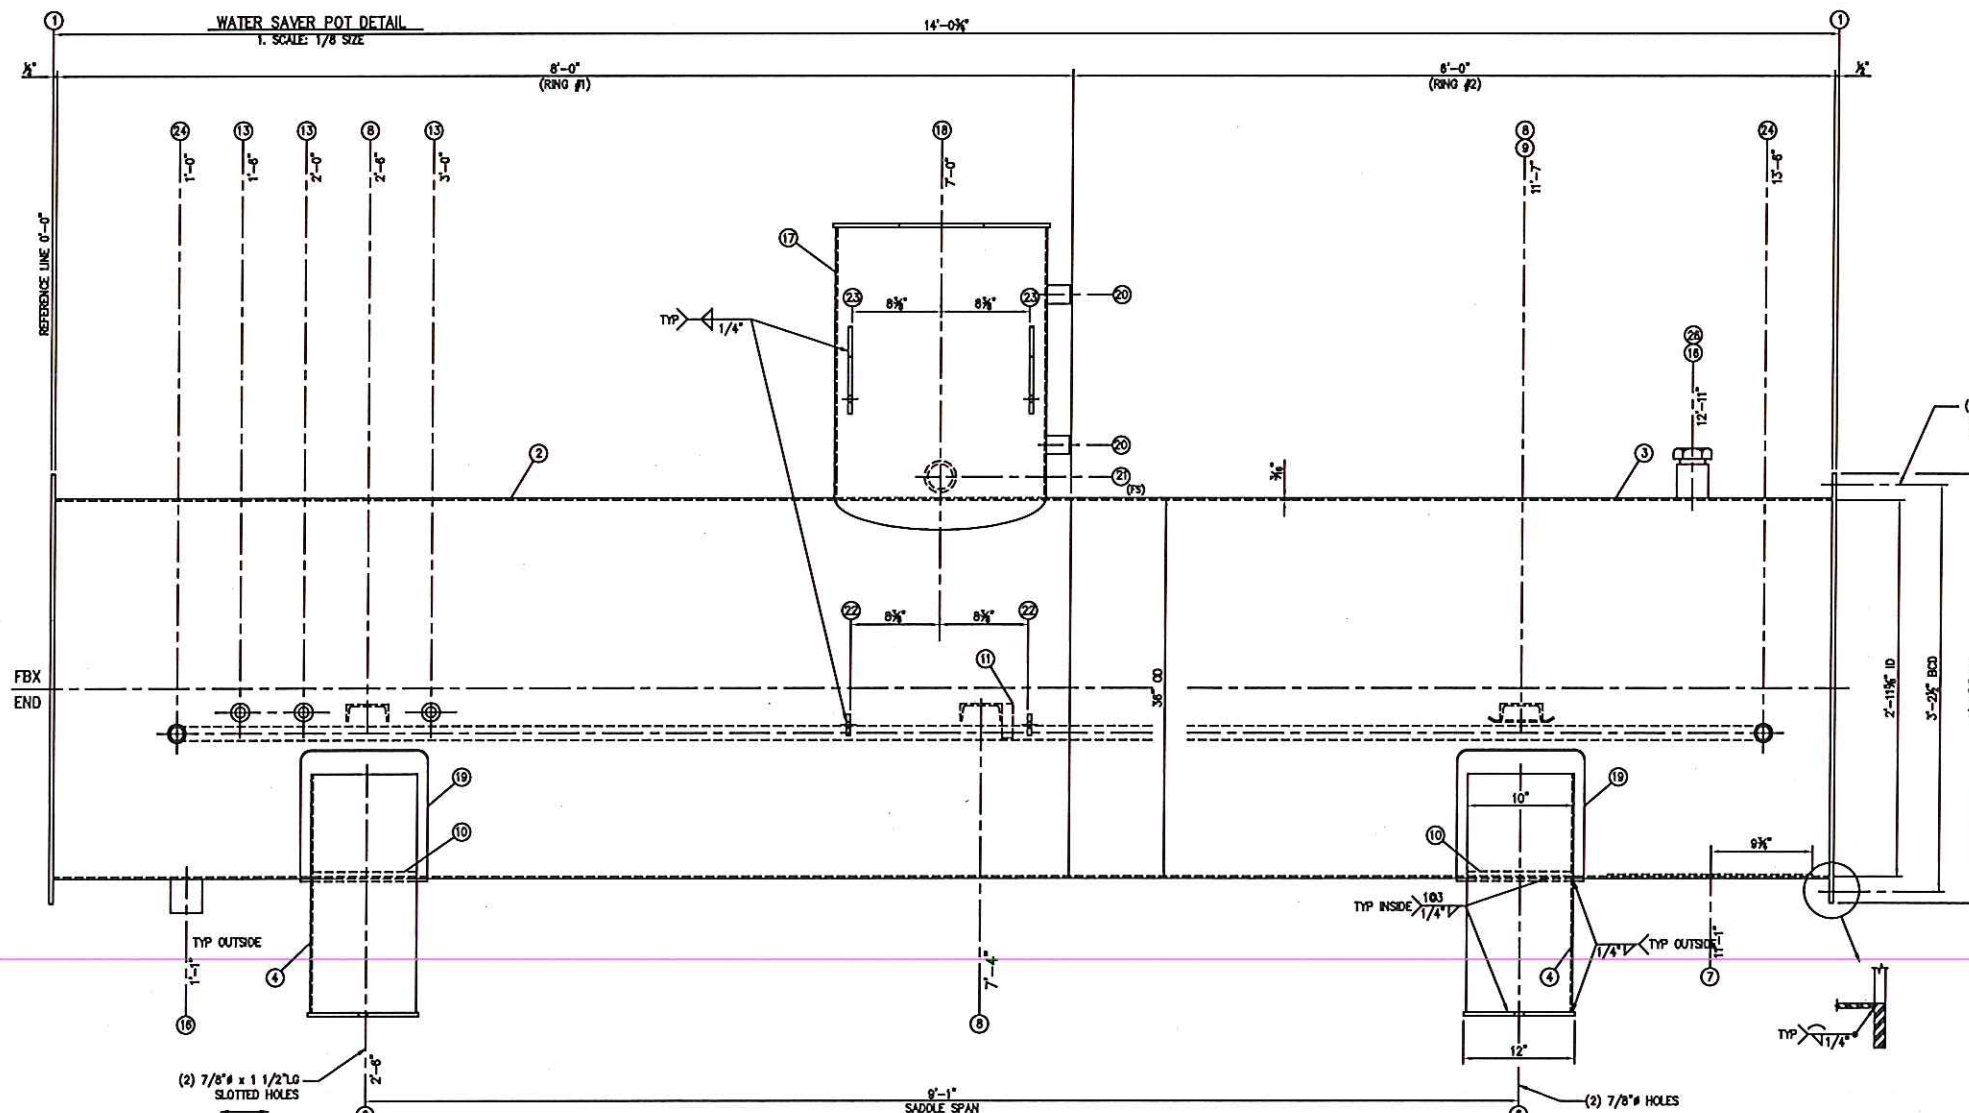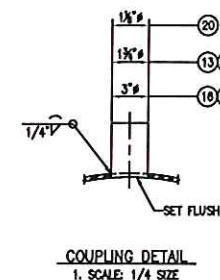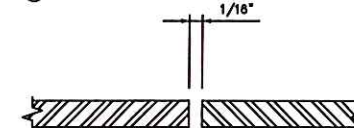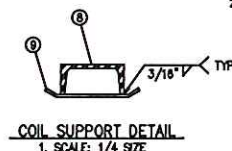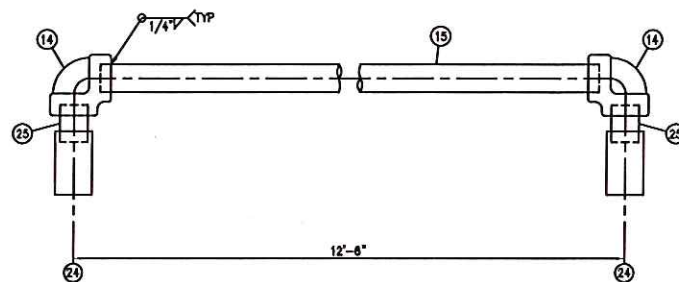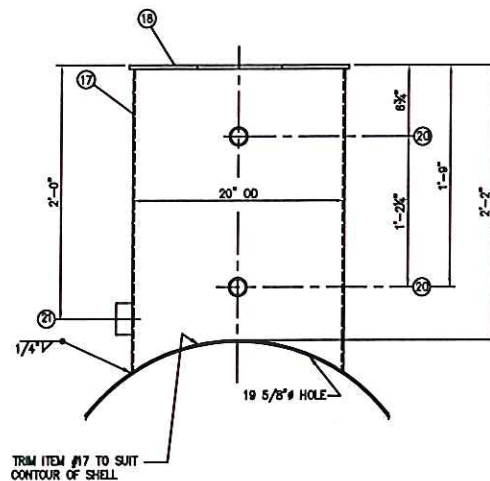


GENERAL NOTES:

- WORKING PRESSURE: 2 PSIG
- AIR TEST: 2 PSIG AND SOAP SEAMS
- ALL DIMENSIONS ON ϕ ARE TO REFERENCE LINE UNO.
- ALL BOLT HOLES TO STRADDLE E'S UNO.
- COMMERCIAL SANDGLAST TO SSPC SP7.
- PAINT: ONE COAT RED OXIDE PRIMER AND ONE COAT WARM GREY ON EXPOSED SURFACES
- INSULATION: 2" AF-530 c/w 0.020" THK STUCCO EMBOSSED ALUMINUM JACKETING
- PROTECT ALL OPENINGS FOR SHIPMENT.
- APPROX. SHIPPING WT: 184 LBS
- QUANTITY REQUIRED: 1

ELEVATION VIEW
1. SCALE: 1/8 SIZE

AS BUILT

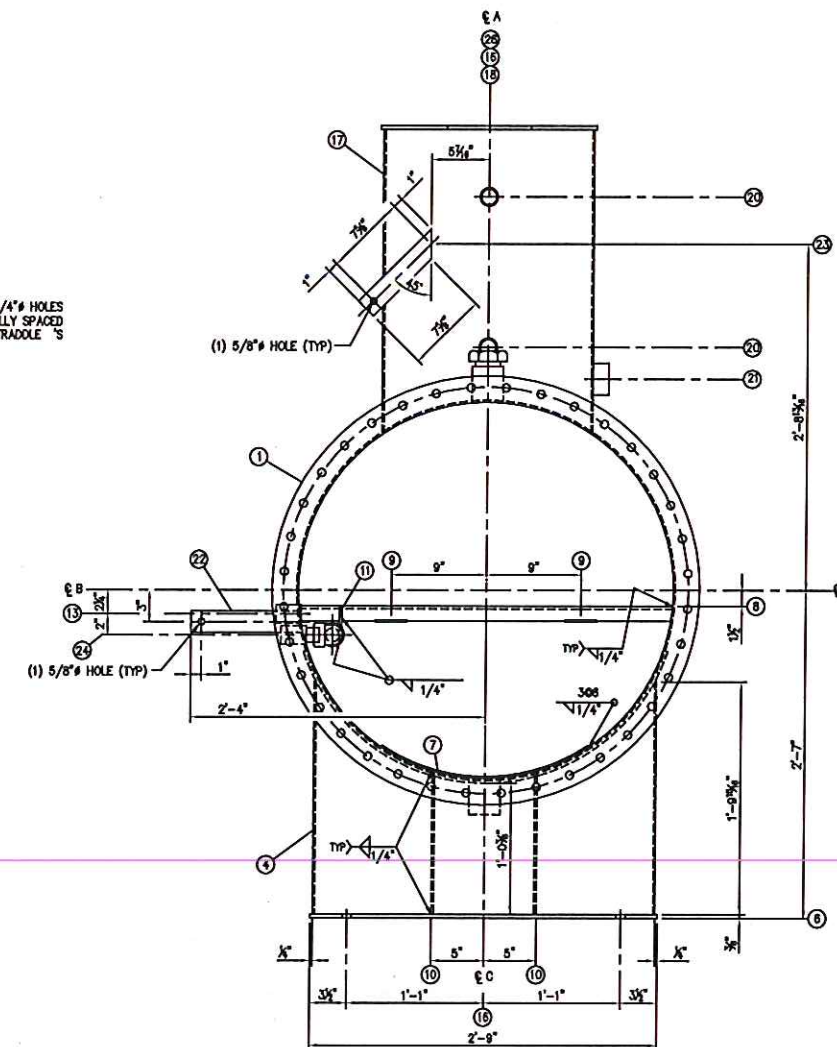

ITEM NO.	PART NO. OR REQ. NO.	QTY. FOR ONE	TOTAL REQ'D	DESCRIPTION	MATERIAL
1		2		40 5/8" OD x 1/2" PL x 30 5/8" ID	44W
2		1		36" OD x 3/16" CYLINDER x 8'-0" LG (BEC)	44W
3		1		36" OD x 3/16" CYLINDER x 8'-0" LG (BEC)	44W
4		1		3'-7 1/2" x 3/16" PL x 3'-10 1/2" LG CHANNEL (OUTS 2 PIECES)	44W
5		2		8" x 3/8" FB x 2'-8" LG	44W
6		1		19 1/2" OD x 3/16" PL (FORM TO ID OF SHELL)	44W
7		3		04 x 5.44 x 2'-11 1/2" LG	44W
8		2		3" x 1/8" PL x 8" LG (BEND AS REQUIRED)	44W
9		2		1'-1 1/4" x 1/4" PL x 1'-0 7/8" LG (OUTS 2 PCS)	SA-36
10		1		1" x 1/4" FB x 3 1/4" LG	44W
11		2		1" CL 3000 NPT FULL CPLG	SA-105N
12		2		1" XH 90° LR BW ELL	SA-234-WPB
13		1		1" XH SMLS PIPE x 12'-3 1/2" LG (BEC)	SA-106-B
14		2		2" CL 3000 NPT FULL CPLG	SA-105N
15		1		20" O.D. WALL EXW PIPE x 2'-5" LG (TRM)	SA-33B
16		1		20 1/2" OD x 3/8" PL x 8" ID	44W
17		2		12" x 1/4" PL x 3'-8" LG (ROLL TO 18" R)	44W
18		2		1/2" CL 3000 NPT FULL CPLG	SA-105N
19		1		2" CL 3000 NPT HALF CPLG	SA-105N
20		2		2" x 3/8" FB x 10 7/16" LG (TRM)	44W
21		2		2" x 3/8" FB x 9 11/16" LG (TRM)	44W
22		2		1" CL 3000 SW x NPT LONG CPLG x 3" LG	SA-105N
23		2		1" XH SMLS PIPE x 1 3/4" LG (BEC)	SA-106-B
24		1		SOLID HEX FLUG 2" NPT	SA-105N

ENERGIRA

COIL END VIEW
1. SCALE: 1/8 SIZE

PO# 23258

SO# 231054

THIS DRAWING IS THE PROPERTY OF FOURSTAR RESOURCES INC. AND IS NOT TO BE REPRODUCED, COPIED, LOANED OR USED WITHOUT ITS PERMISSION.

FOURSTAR RESOURCES INC.
NISKU, ALBERTA, CANADA36" OD x 14'-0" LG SHELL
FOR FSR750IH RH MOUNT
INDIRECT HEATER SHELL

DRAWN BY: WT JUL07/23

DATE CHECKED BY: WT JUL07/23

APPROVED BY: WT JUL07/23


DATE BUILT: 1/8 SIZE

DRAWING NO. 231054SHELL-LH01


REV.	DESCRIPTION	BY	CHK'D	DATE
0	RE-ISSUED FOR CONSTRUCTION	WT	WT	AUG02/23

FSR
INC

231054SHELL-LH02

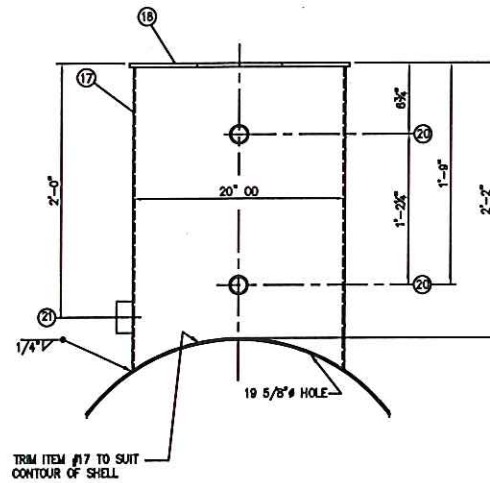


WATER SAVER POT DETAIL
1. SCALE: 1/8 SIZE

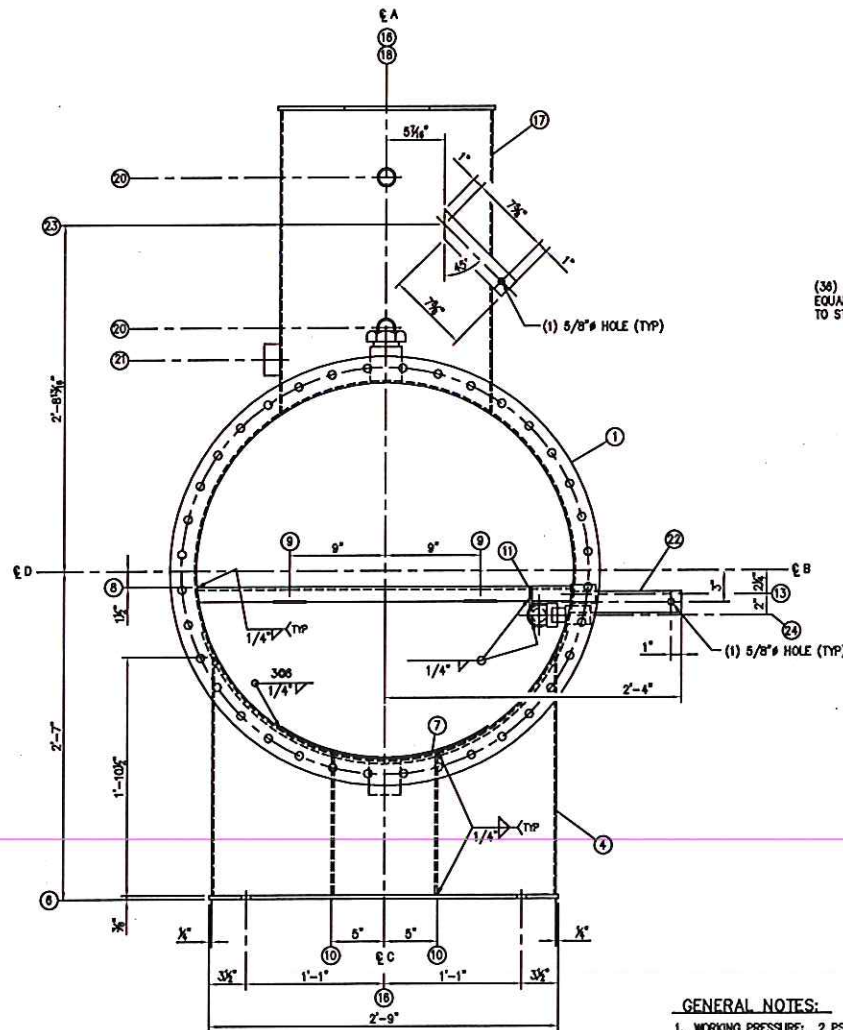


COIL END VIEW
1. SCALE: 1/8 SIZE

GENERAL NOTES:


1. WORKING PRESSURE: 2 PSIG
2. AIR TEST: 2 PSIG AND SOAP SEAMS
3. ALL DIMENSIONS ON O — ARE TO REFERENCE LINE UNO.
4. ALL BOLT HOLES TO STRADDLE E'S UNO.
5. COMMERCIAL SANDBLAST TO SSPG SP7.
6. PAINT: ONE COAT RED OXIDE PRIMER AND ONE COAT WARM GREY ON EXPOSED SURFACES
7. INSULATION: 2" AF-530 c/w 0.020" THK STUCCO EMBOSSED ALUMINUM JACKETING
8. PROTECT ALL OPENINGS FOR SHIPMENT.
9. APPROX. SHIPPING WT.: TBA ILL
10. QUANTITY REQUIRED: 1

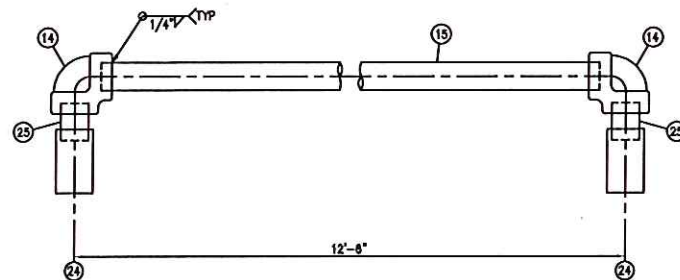

 
PREHEAT COIL DETAIL
1. SCALE: 1/4 SIZE
2. HYDROTEST @ 2220 PSIG AFTER INSTALLING IN VESSEL




COIL SUPPORT DETAIL
1. SCALE: 1/4 SIZE

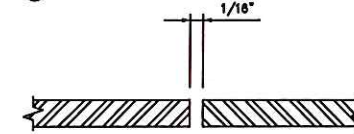

WELD DETAIL - SHELL SEAM
1. NTS

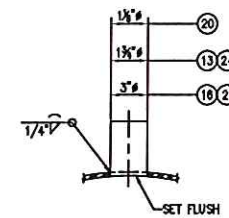

COUPLING DETAIL
1. SCALE: 1/4 SIZE

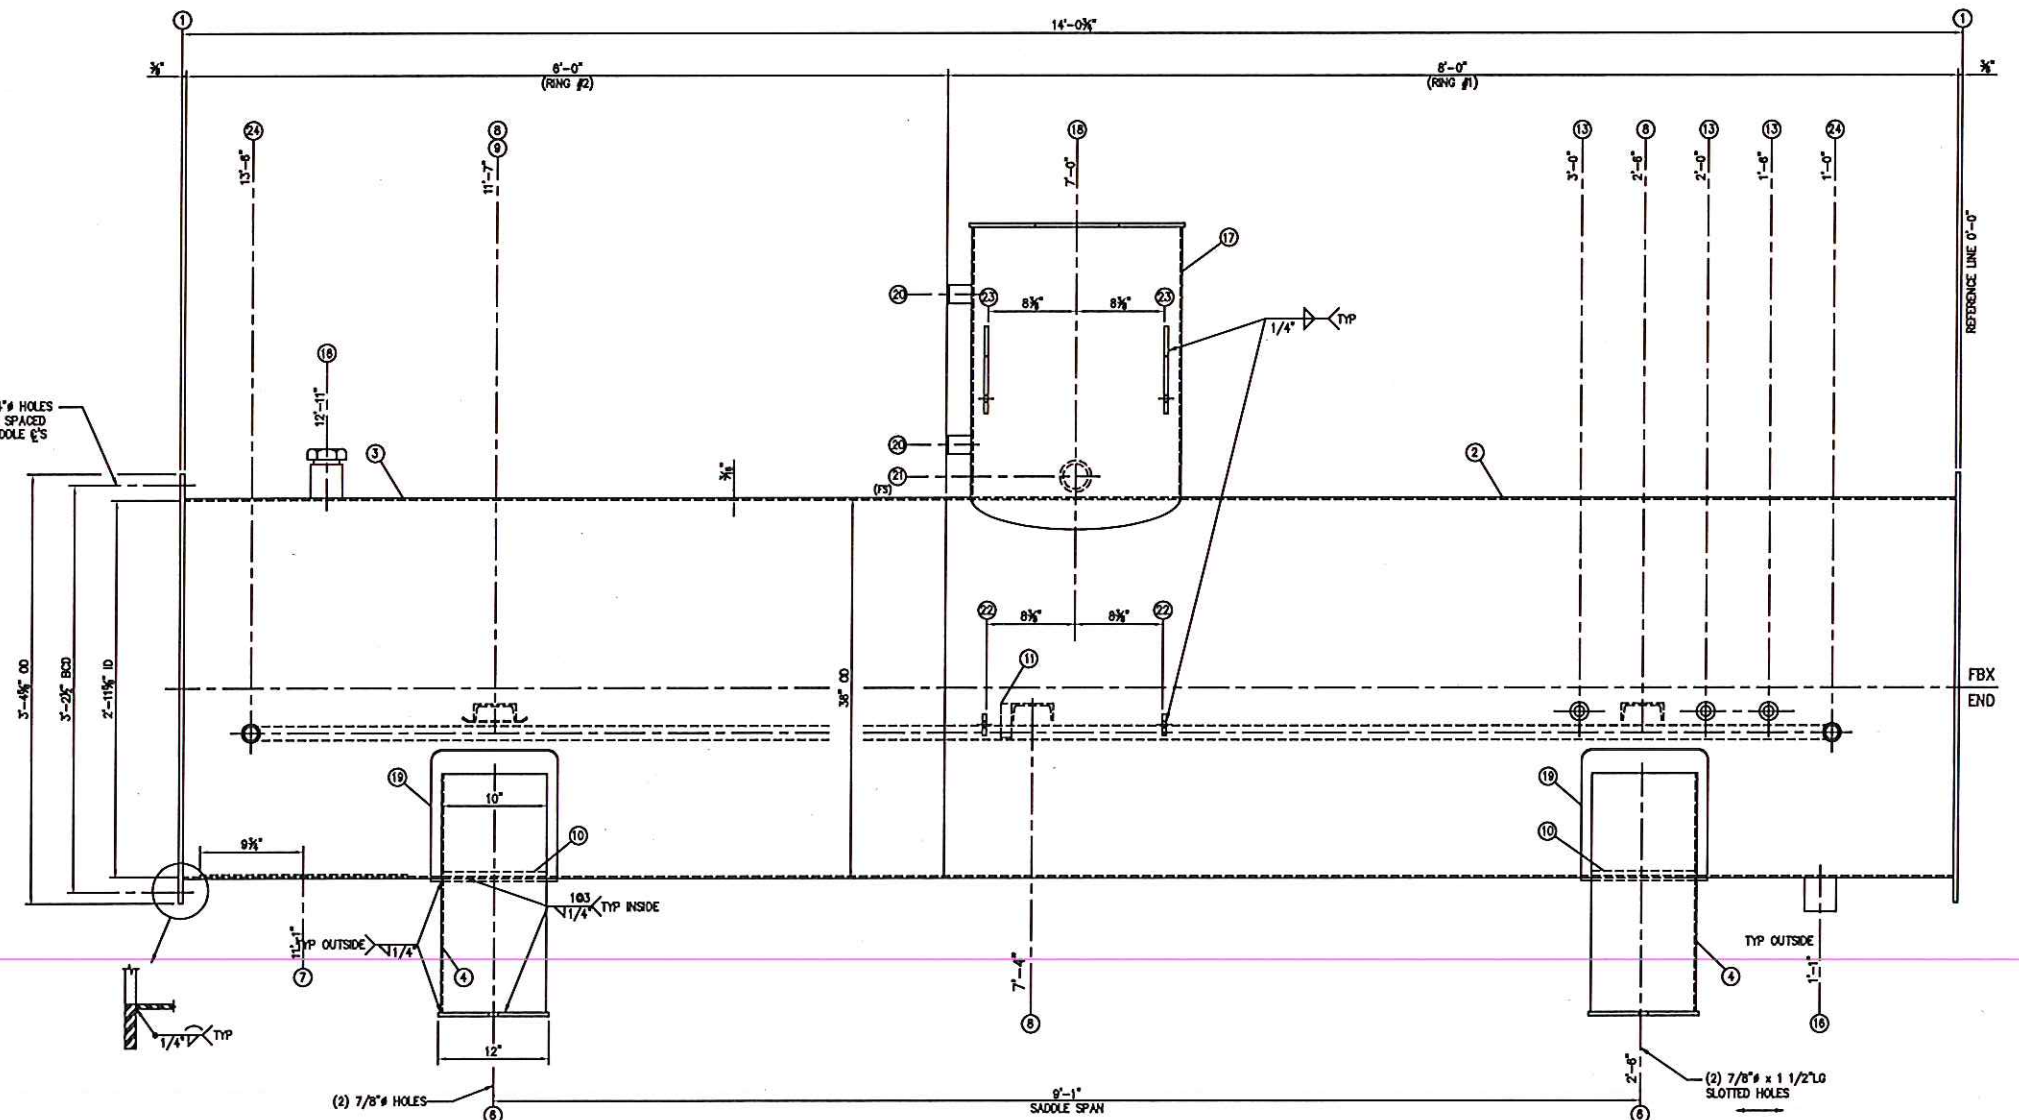

AS BUILT


ELEVATION VIEW
1. SCALE: 1/8 SIZE

ITEM NO.	PART NO. OR REQ. NO.	QTY. FOR ONE	TOTAL QTY. REQ'D	DESCRIPTION	MATERIAL
1		2		40 5/8" OD x 3/8" PL x 35 5/8" ID	44W
2		1		36" OD x 3/16" CYLINDER x 8'-0" LG (BEE)	44W
3		1		36" OD x 3/16" CYLINDER x 8'-0" LG (BEE)	44W
4		1		3'-7 1/2" x 3/16" PL x 3'-10 1/2" LG CHANNEL	44W
				(OUTS 2 PEECES)	
6		2		8" x 3/8" FB x 2'-0" LG	44W
7		1		19 1/2" OD x 3/16" PL (FORM TO ID OF SHELL)	44W
8		3		04 x 5.48 x 2'-11 1/2" LG	44W
9		2		3" x 1/8" PL x 8" LG (BEND AS REQUIRED)	44W
10		2		1'-1 1/4" x 1/4" PL x 1'-0 7/8" LG (OUTS 2 PCS)	SA-36
11		1		1" x 1/4" FB x 3 1/4" LG	44W
13		2		1" CL 3000 NPT FULL CPLG	SA-105N
14		2		1" XH 60" LR BW ELL	SA-234-WPB
15		1		1" XH SMLS PIPE x 12'-3 1/2" LG (BEE)	SA-106-B
16		2		2" CL 3000 NPT FULL CPLG	SA-105N
17		1		20" 0.188" WALL EXW PIPE x 2'-5" LG (TRM)	SA-53B
18		1		20 1/2" OD x 3/8" PL x 8" ID	44W
19		2		12" x 1/4" PL x 3'-0" LG (ROLL TO 16" R)	44W
20		2		1/2" CL 3000 NPT FULL CPLG	SA-105N
21		1		2" CL 3000 NPT HALF CPLG	SA-105N
22		2		2" x 3/8" FB x 10 7/8" LG (TRM)	44W
23		2		2" x 3/8" FB x 9 11/16" LG (TRM)	44W
24		2		1" CL 3000 SW x NPT LONG CPLG x 3" LG	SA-105N
25		2		1" XH SMLS PIPE x 1 3/4" LG (PBE)	SA-106-B
26		1		SOLID HEX FLUG 2"NPT	SA-105N


REV.	DESCRIPTION	BY	CHK'D	DATE
0	RE-ISSUED FOR CONSTRUCTION	WT	WT	JUL07/23

ENERGIRA	PO# 23258	SO# 231054
FSR INC	FOURSTAR RESOURCES INC. NISKU, ALBERTA, CANADA	36" OD x 14'-0" LG SHELL FOR FSR750IH LH MOUNT INDIRECT HEATER SHELL
DATE FORWARDED BY: JUL07/23	DATE: JUL07/23	DATE: JUL07/23
APPROVED BY: WT	DATE: JUL07/23	1/8 SIZE
		DRAWING NO. 231054SHELL-LH02

231054SKID-LH01

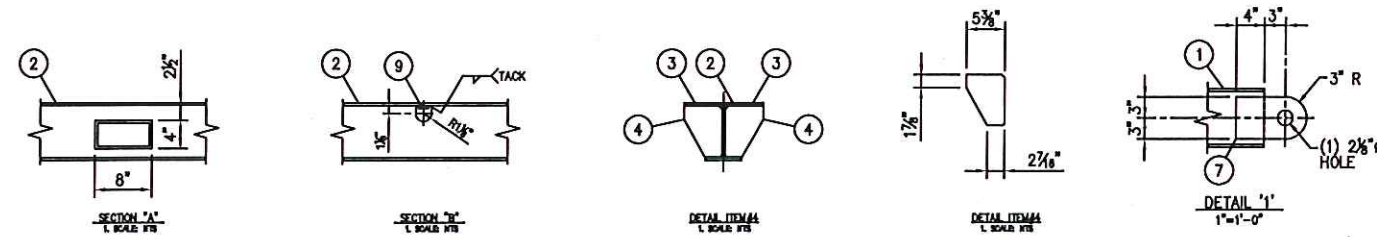

ITEM NO.	PART NO. OR REQ. NO.	QTY. FOR ONE	TOTAL QTY. REQ'D	DESCRIPTION	MATERIAL
1		2		W8 x 18# x 21'-0" LG	CSA G40.21 50W
2		4		W8 x 18# x 3'-6 1/2" LG	CSA G40.21 50W
3		4		FB 3/8" x 4" x 3'-1 1/2" LG	44W
4		8		PL 3/8" x 5 3/8" x 7 1/4"	44W
5		2		HSS 8" x 4 x 1/4" x 3'-7" LG	44W
6		4		1" x 2" LG HEX HD BOLT	A325
7		4		6" x 1/2" PL x 10" LG (SEE DETAIL)	44W
FOR				FURNISH FOR ASSEMBLY	
9		4		1" HEX NUT HD	SA-194-2H

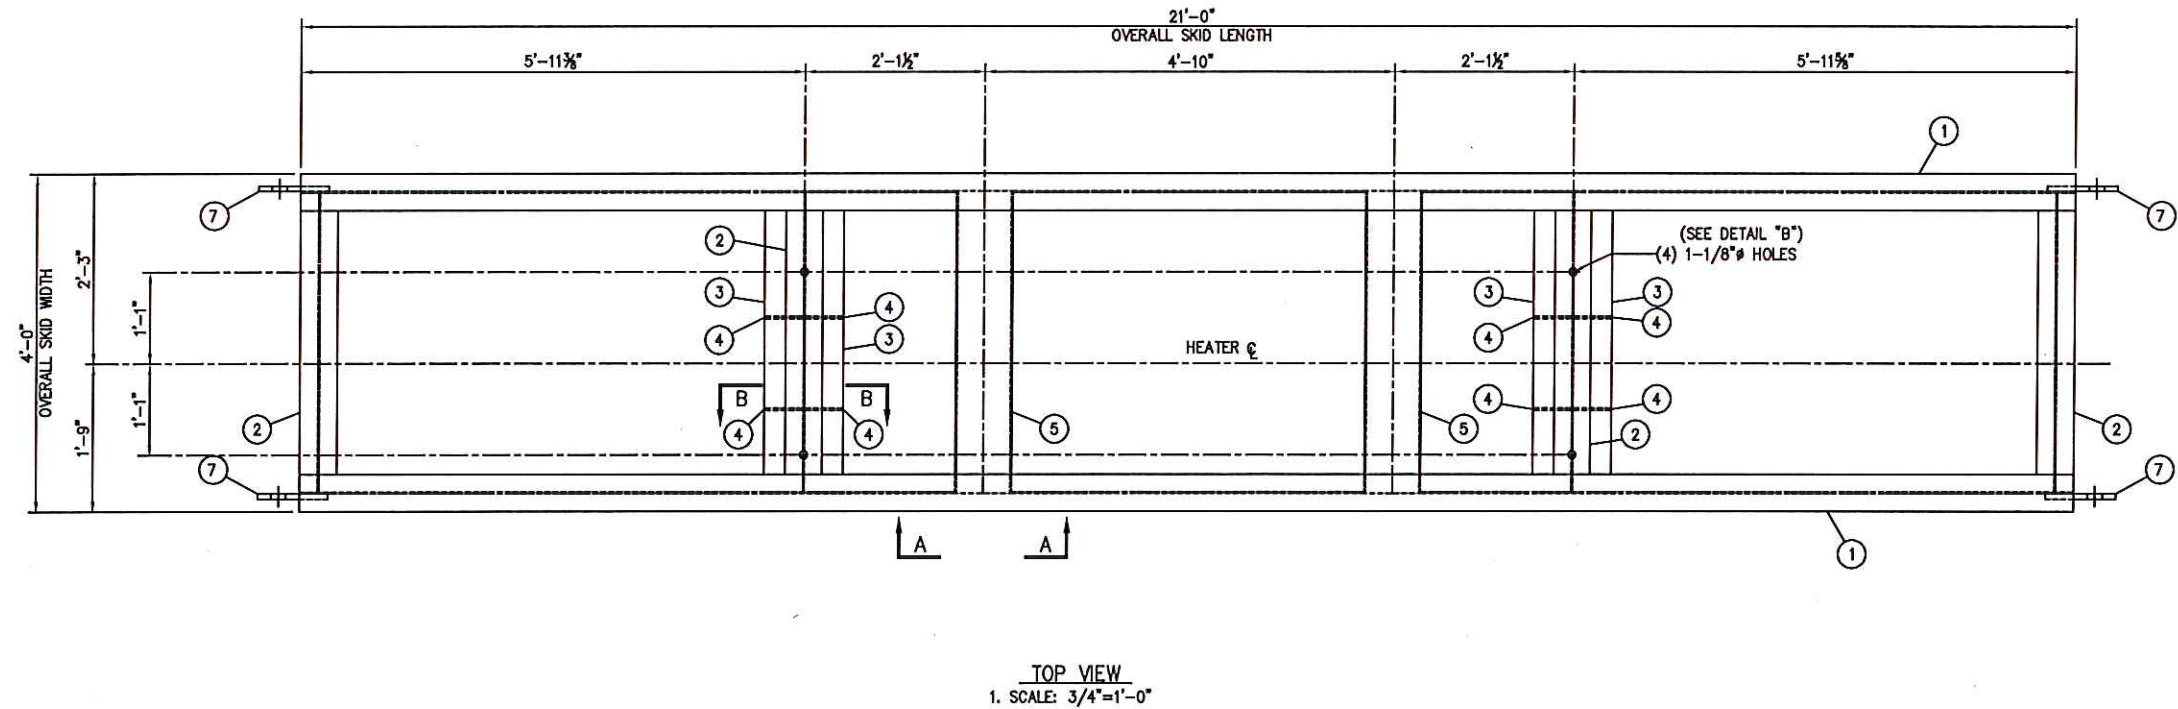

AS BUILT


GENERAL NOTES:

- ALL STRUCTURAL MEMBERS
- ALL STRUCTURAL MEMBERS TO BE FLUSH WITH TOP OF SKID UNO.
- COPE STRUCTURAL MEMBERS WHERE APPLICABLE UNO.
- COMMERCIAL SANDBLAST TO SSPC SP6.
- PAINT: PER PROJECT DATA LIST
- APPROX. WT.: 750lbs
- QTY REQ'D: 1

REV.	DESCRIPTION	BY	CHK'D	DATE
0	ISSUED FOR CONSTRUCTION	WT	WT	AUG23/23
B	RE-ISSUED FOR APPROVAL	WT	WT	AUG04/23

ENERGERA	PO# 23258	SO# 231054
THIS DRAWING IS THE PROPERTY OF FOURSTAR RESOURCES INC. AND IS NOT TO BE PRINTED, PHOTOGRAPHED, COPIED, LOANED OR USED WITHOUT ITS PERMISSION		
FSR INC	FOURSTAR RESOURCES INC. NISKU, ALBERTA, CANADA	4'-0" x 21'-0" LG SKID FOR FSR750IH RH MOUNT INDIRECT HEATER
DRAWN BY: WT	DATE: AUG04/23	CHECKED BY: WT
DATE: AUG04/23	SCALE: AS SHOWN	DRAWING NO. 231054SKID-LH01

231054SKID-LH02					ITEM NO.	PART NO. OR REQ. NO.	QTY. FOR ONE	TOTAL QTY. REQ'D	DESCRIPTION	MATERIAL
					1		2		W8 x 18# x 21'-0" LG	CSA G40.21 50W
					2		4		W8 x 18# x 3'-6 1/2" LG	CSA G40.21 50W
					3		4		FB 3/8" x 4" x 3'-1 1/2" LG	44W
					4		8		PL 3/8" x 5 3/8" x 7 1/4"	44W
					5		2		HSS 8" x 4 x 1/4" x 3'-7" LG	44W
					6		4		1" x 2" LG HEX HD BOLT	A325
					7		4		6" x 1/2" PL x 10" LG (SEE DETAIL)	44W
					FOR				FURNISH FOR ASSEMBLY	
					9		4		1" HEX NUT HD	SA-194-2H

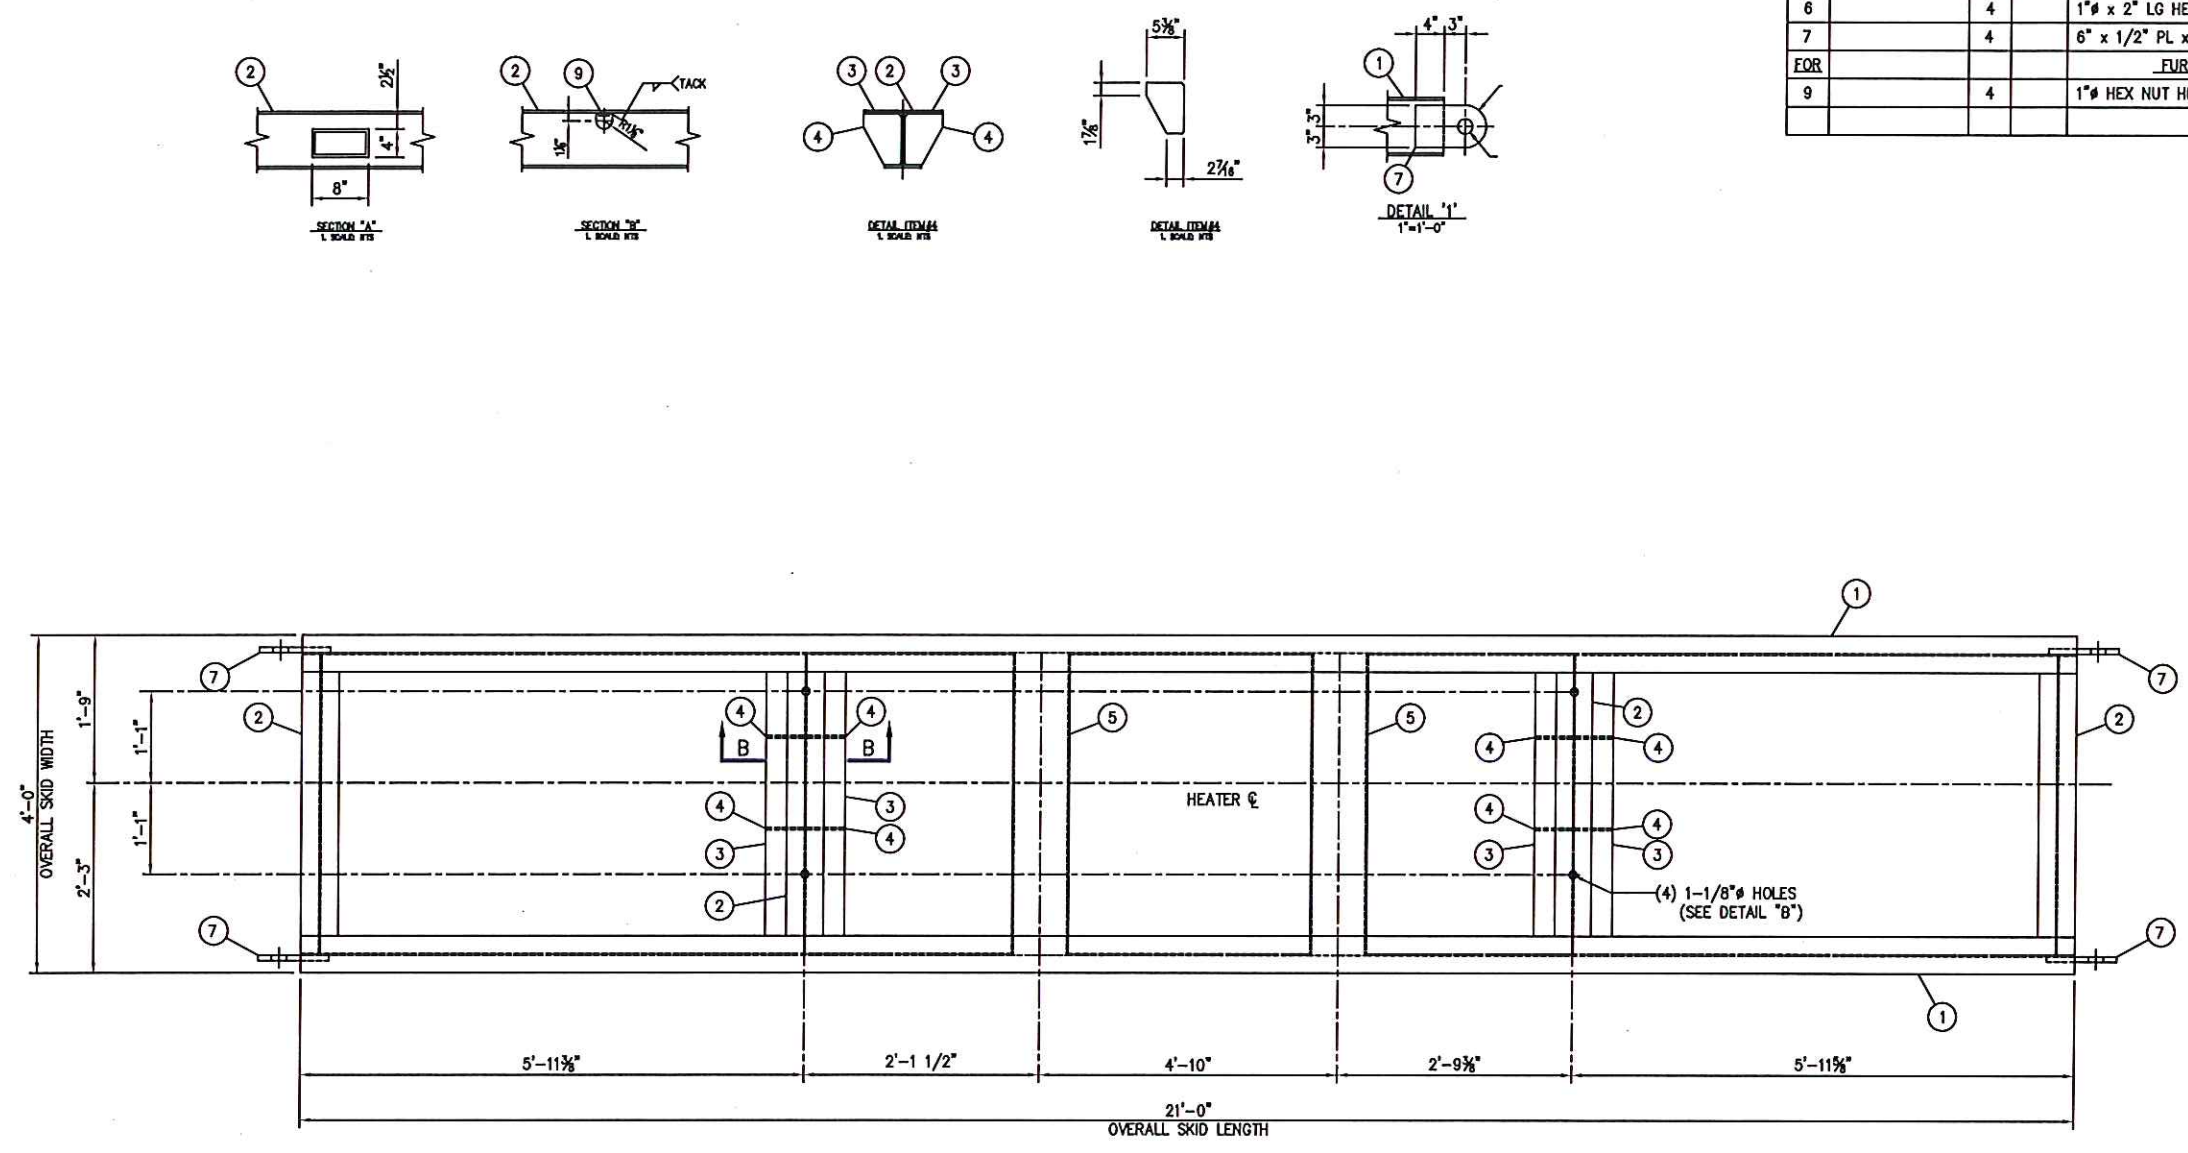


TOP VIEW
1. SCALE: 3/4"=1'-0"

AS BUILT

- GENERAL NOTES:
- 1. ALL STRUCTURAL MEMBERS TO BE FLUSH WITH TOP OF SKID UNO.
 - 2. ALL STRUCTURAL MEMBERS TO BE FLUSH WITH TOP OF SKID UNO.
 - 3. COPE STRUCTURAL MEMBERS WHERE APPLICABLE UNO.
 - 4. COMMERCIAL SANDBLAST TO SSPC SP6.
 - 5. PAINT: PER PROJECT DATA LIST
 - 6. APPROX. WT.: 750lbs.
 - 7. QTY REQ'D: 1

ENERGERA				PO# 23258				SQ# 231054			
THIS DRAWING IS THE PROPERTY OF FOURSTAR RESOURCES INC. AND IS NOT TO BE PRINTED, PHOTOGRAPHED, COPIED, LOANED OR USED WITHOUT ITS PERMISSION											
FSR INC				FOURSTAR RESOURCES INC. NISKU, ALBERTA, CANADA				4'-0" x 21'-0 " LG SKID FOR FSR750IH LH MOUNT INDIRECT HEATER			
				DRAWN BY: WT		DATE AUG04/23		CHECKED BY: WT		DATE AUG04/23	
				APPROVED BY: WT		DATE AUG04/23		SCALE: AS SHOWN		DRAWING NO. 231054SKID-LH02	
O		ISSUED FOR CONSTRUCTION		WT		WT		AUG23/23			
B		RE-ISSUED FOR APPROVAL		WT		WT		AUG04/23			
REV.		DESCRIPTION		BY		CHK'D		DATE			

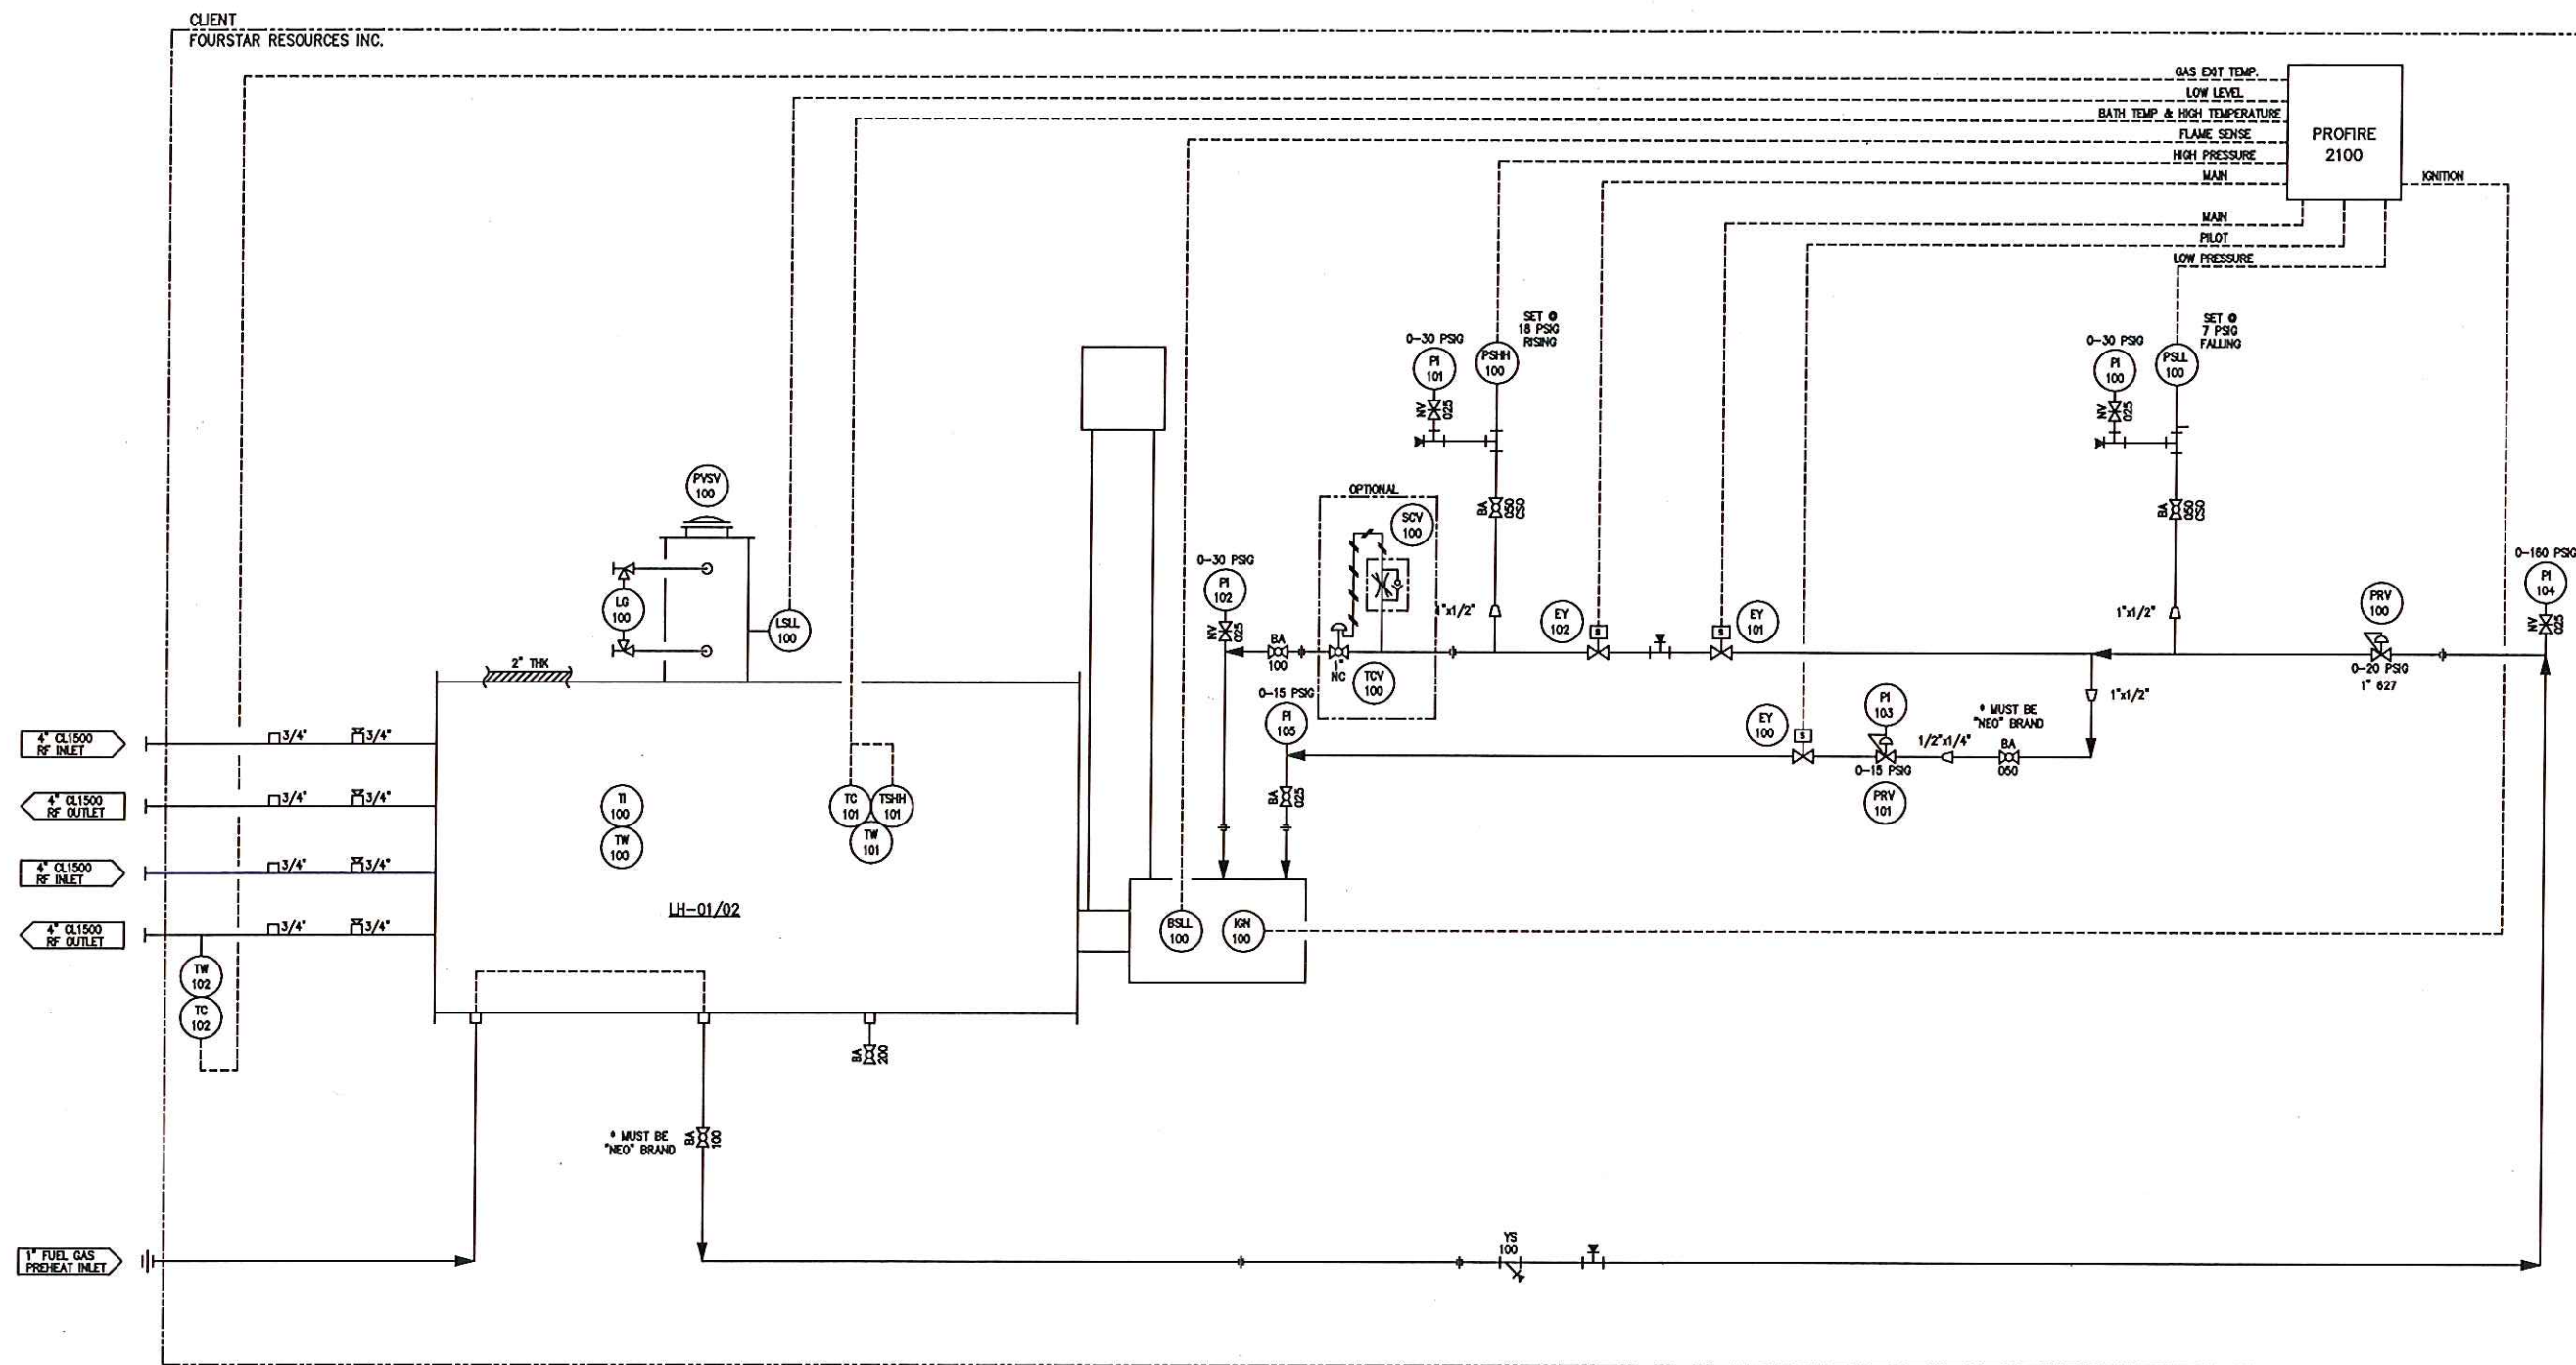

LEGEND

	PNEUMATIC SIGNAL
	ELECTRIC SIGNAL
	FUEL GAS PIPING
	INSTRUMENT GAS
	DIRECTION OF FLOW

LH-01/02
MODEL: 750 IH (LEFT HAND MOUNT)
SIZE: 36" OD x 14'-0" LG
COIL: PREHEAT 4" 8-TUBE/REHEAT 4" 4-TUBE
M.A.W.P.: 3270 PSIG
DESIGN TEMP.: 300°F
M.D.M.T.: -50°F
G.A.: 1/16"
RADIOGRAPHY: 10%


GENERAL NOTES:

1. ALL NPT FITTINGS TO BE CL 2000 OR 3000 SA-105H
2. ALL PIPE AND NIPPLES TO BE SCH 80 SA-106B


AS BUILT

						ENERGERA		P# 23258		SQ# 231054	
						THIS DRAWING IS THE PROPERTY OF FOURSTAR RESOURCES INC. AND IS NOT TO BE REPRODUCED, PHOTOGRAPHED, COPIED, LOANED OR USED WITHOUT ITS PERMISSION					
						FSR INC		FOURSTAR RESOURCES INC. NISKU, ALBERTA, CANADA		P&ID FOR FSR INDIRECT HEATER W/ PROFIRE 2100	
								DRAWN BY MM DATE DESIGNED BY DATE MAY27/18 WT MAY27/18		DRAWING NO. 231054PID-LH01/02	
								APPROVED BY MM DATE SCALE MAY27/18 NTS			
O		ISSUED FOR CONSTRUCTION		WT	WT	AUG21/23					
C		RE-ISSUED FOR APPROVAL		WT	WT	AUG14/23					
REV.		DESCRIPTION		BY	CHK'D	DATE					

231054COIL-LH01

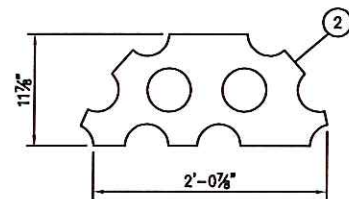

COIL SUPPORT DETAIL
ITEM #2

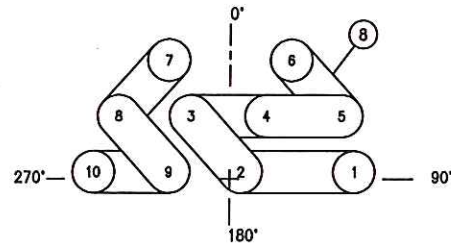


TUBE NUMBERING AND
RETURN BEND LAYOUT

TUBES #6,7,10
TUBES #3-5 & 8-9


TUBES #2

TUBES #1

ITEM NO.	PART NO.	QTY.	DESCRIPTION	MATERIAL	WT.
1		1	PL 40 5/8" OD x 3/8" PL	SA-36/44W	
2		3	11-7/8" x 1/4" PL x 2'-0 7/8" LG (TRIM)	SA-36/44W	
3		1	NAME PL	ST STL	
4		1	NAME PL BRACKET	SA-36/44W	
5		4	4" CL 1500 RFWN FLG w/SCH 160 BORE	SA-350LF2CL1	
6		3	4" SCH 160 SMLS PIPE x 14'-2 1/16" LG (BBE)	SA-333GR6	
7		5	4" SCH 160 SMLS PIPE x 12'-1 7/8" LG (BBE)	SA-333GR6	
8		7	4" SCH 160 180° SR BW RETURN BEND	SA-420WPL6	
9		1	4" SCH 160 180° LR BW RETURN BEND	SA-420WPL6	
10		1	4" SCH 160 SMLS PIPE x 11'-11 7/8" LG (BBE)	SA-333GR6	
11		8	3/4"CL6000 TOL (4)	SA-350LF2CL1	
12		4	3/4"CL6000 HEX PLUG	SA-350LF2CL1	
13		1	4" SCH 160 SMLS PIPE x 14'-0" LG (BBE)	SA-333GR6	
FOR FURNISH & INSTALL					
1		1	GSKT 40 5/8" OD x 1/8" x 35 5/8" ID w/(36) 3/4" #	NA-60	
			HOLES EQUALLY SPACED ON 38 1/2" BCD		
1		36	5/8" # x 1 1/2" LG HEX HD BOLT	SAE-J429GR.5	
1		36	5/8" # HEX NUT	SA-194-2H	

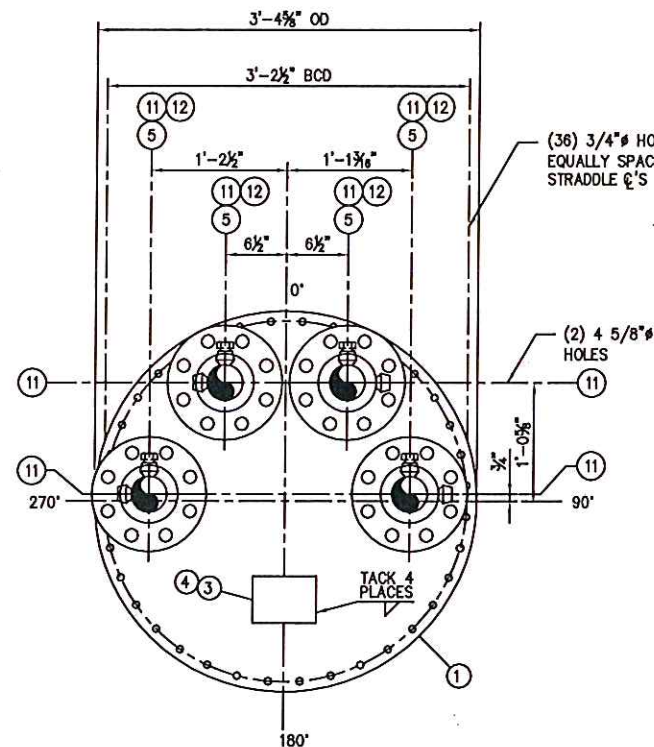

END VIEW

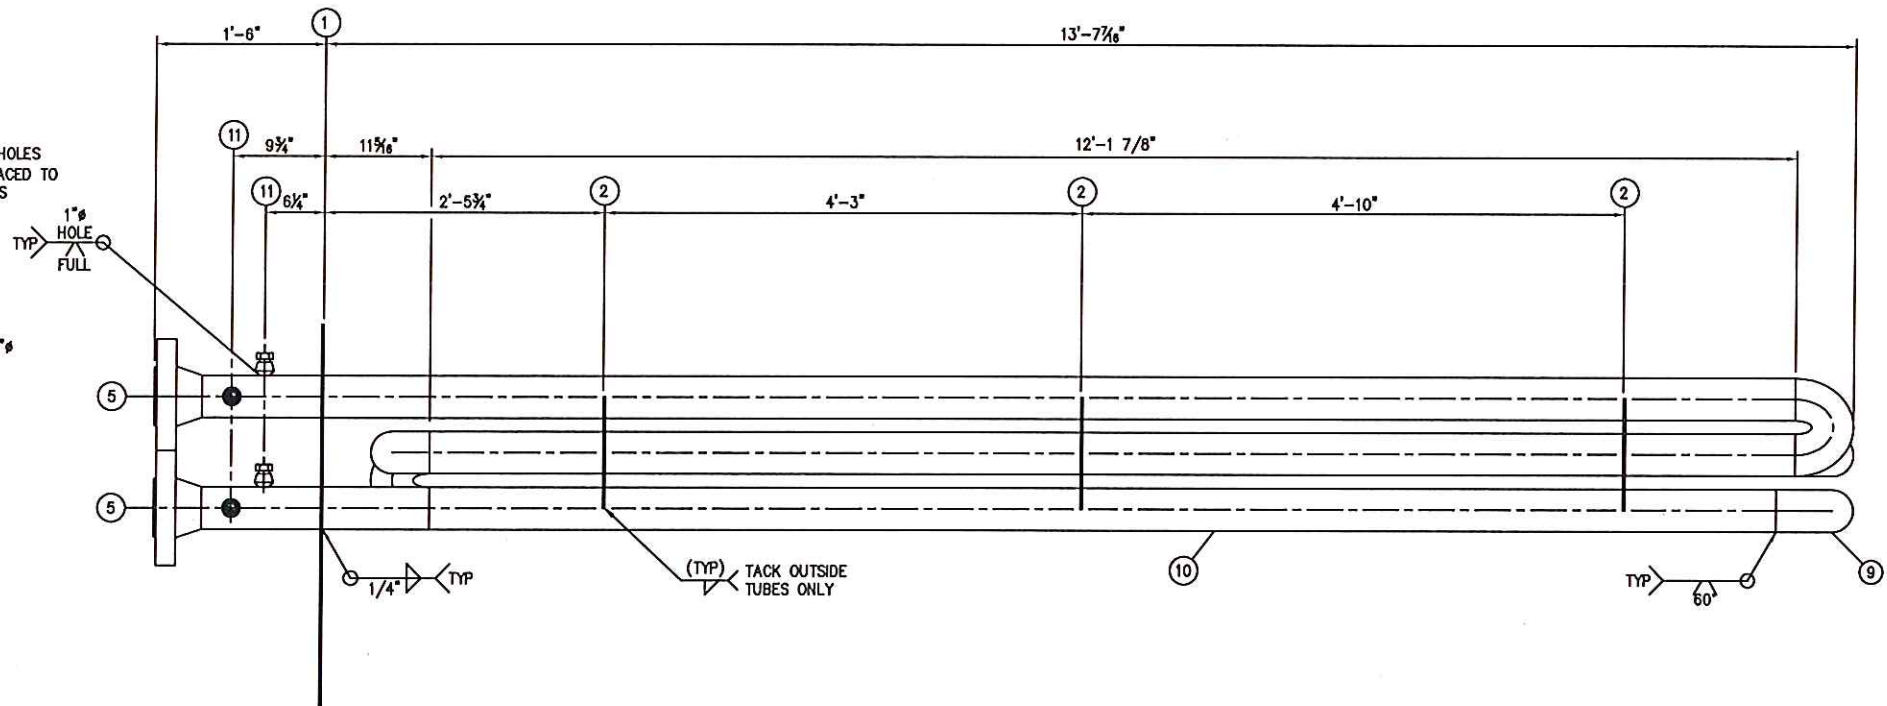

SIDE VIEW

GENERAL NOTES:

1. TO BE BUILT IN ACCORDANCE WITH ASME PRESSURE PIPING CODE B31.3, 2022 EDITION.
2. IMPACT TEST EXEMPT AS PER TABLE 323.2.2A.
3. WELD PROCEDURE: WPS-1/LT-8
4. COMMERCIAL SANDBLAST TO SSPC SP7.
5. PAINT: ONE COAT PRIMER AND TWO COATS WARM GREY ENAMEL ON EXPOSED SURFACES.
6. INSULATION: NONE
7. PLUG ALL OPENINGS FOR SHIPMENT.
8. APPROX. WT.: 3600 lbs.
9. QTY. 1 REQUIRED.

	COIL #1 6-TUBES PREHEAT	COIL #2 4-TUBES REHEAT	
M.A.W.P. @ 300°F	3270 PSIG	3270 PSIG	
M.D.M.T.	-50°F	-50°F	
LTD. BY	FLANGES	FLANGES	
HYDROTEST	4905 PSIG	4905 PSIG	
C.A.	0.0625"	0.0625"	
RADIOGRAPHY	10%	10%	
HEATING SURFACE	99 sq ft	66 sq ft	
VOLUME	9.2 cu ft	6.2 cu ft	
CRN	T2005.2	T2005.2	
PWHT		NONE	

0	ISSUED FOR CONSTRUCTION	WT	WT	AUG23/23
B	RE-ISSUED FOR APPROVAL	WT	WT	AUG02/23
REV.	DESCRIPTION	BY	CHK'D	DATE




FSR
INC

FOURSTAR RESOURCES INC.
NISKU, ALBERTA, CANADA
DATE CHECKED BY: JUL07/23
DATE SCALE: JUL07/23 3/4" = 1'-0"


4"-(10) TUBE 3270 PSIG
DUAL PASS COIL FOR FSR
MODEL 750IH INDIRECT HEATER
DRAWING NO.
231054COIL-LH01

AS BUILT

231054COIL-LH02

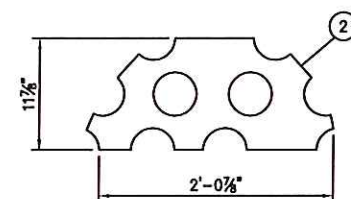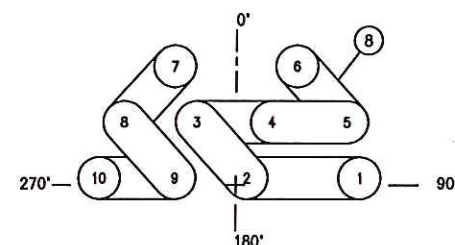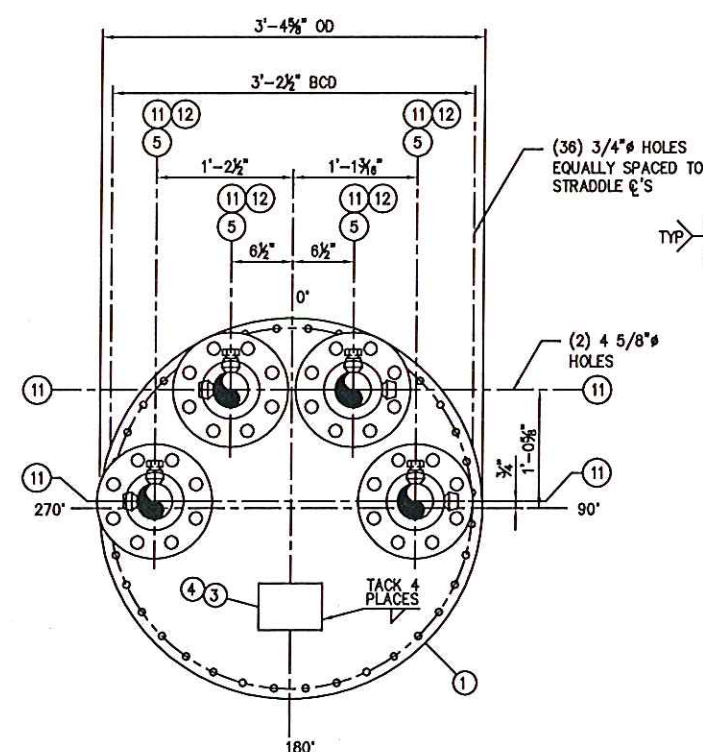COIL SUPPORT DETAIL
ITEM #2TUBE NUMBERING AND
RETURN BEND LAYOUT

END VIEW

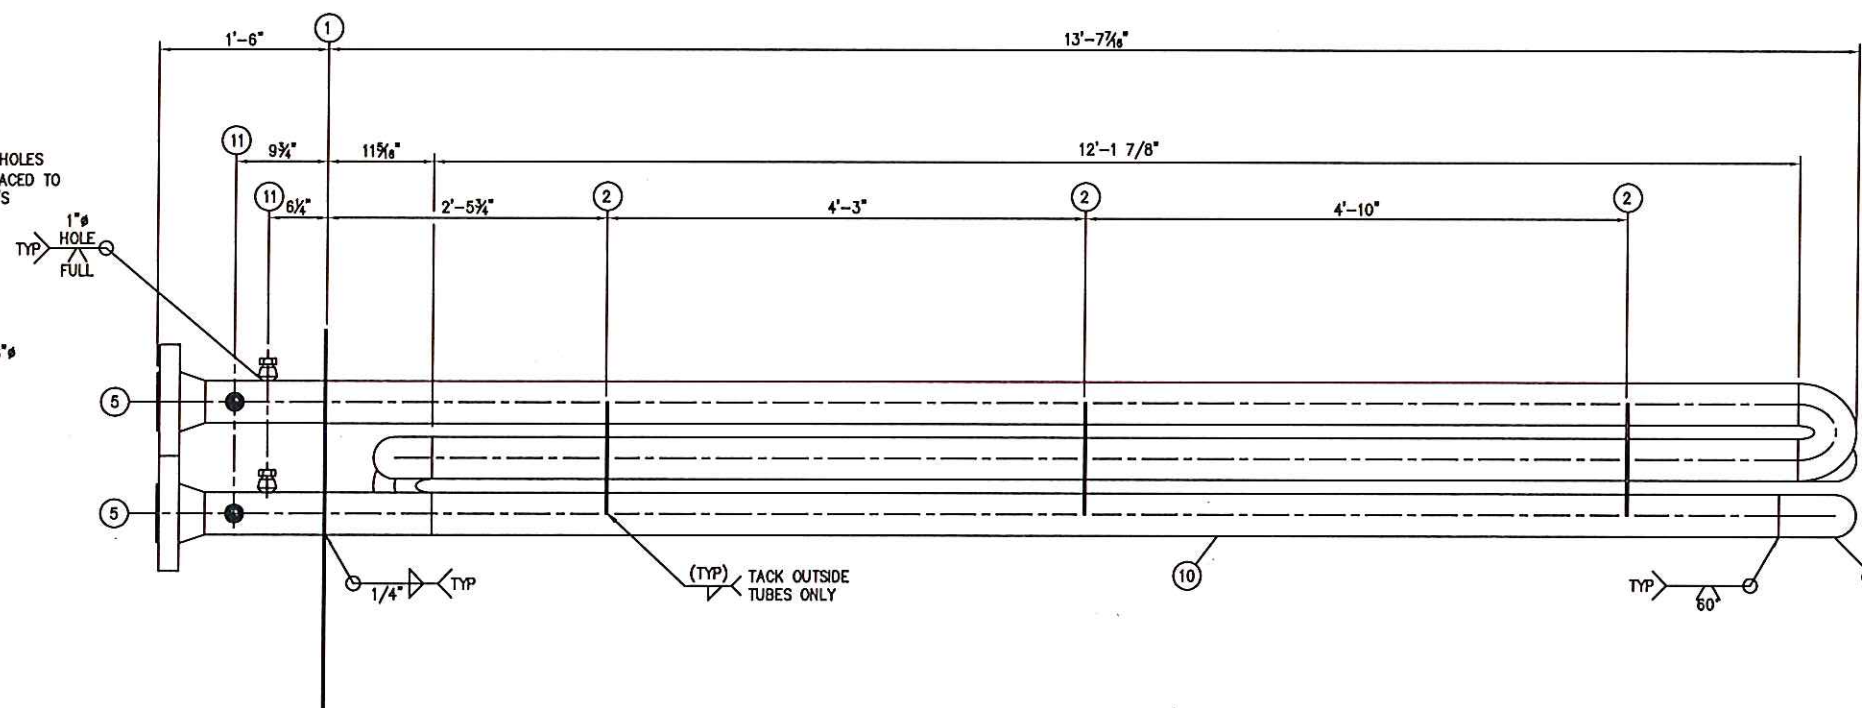

SIDE VIEW

ITEM NO.	PART NO.	QTY.	DESCRIPTION	MATERIAL	WT.
1		1	PL 40 5/8" OD x 3/8" PL	SA-36/44W	
2		3	11-7/8" x 1/4" PL x 2'-0 7/8" LG (TRIM)	SA-36/44W	
3		1	NAME PL	ST STL	
4		1	NAME PL BRACKET	SA-36/44W	
5		4	4" CL 1500 RFWN FLG w/SCH 160 BORE	SA-350LF2CL1	
6		3	4" SCH 160 SMLS PIPE x 14'-2 1/16" LG (BBE)	SA-333GR6	
7		5	4" SCH 160 SMLS PIPE x 12'-1 7/8" LG (BBE)	SA-333GR6	
8		7	4" SCH 160 180° SR BW RETURN BEND	SA-420WPL6	
9		1	4" SCH 160 180° LR BW RETURN BEND	SA-420WPL6	
10		1	4" SCH 160 SMLS PIPE x 11'-11 7/8" LG (BBE)	SA-333GR6	
11		8	3/4"CL6000 TOL (4)	SA-350LF2CL1	
12		4	3/4"CL6000 HEX PLUG	SA-350LF2CL1	
13		1	4" SCH 160 SMLS PIPE x 14'-0" LG (BBE)	SA-333GR6	
FOR FURNISH & INSTALL					
1		1	GSKT 40 5/8" OD x 1/8" x 35 5/8" ID w/(36) 3/4"	NA-60	
			HOLES EQUALLY SPACED ON 38 1/2" BCD		
1		36	5/8" x 1 1/2" LG HEX HD BOLT	SAE-J429GR.5	
1		36	5/8" HEX NUT	SA-194-2H	

GENERAL NOTES:

- TO BE BUILT IN ACCORDANCE WITH ASME PRESSURE PIPING CODE B31.3, 2022 EDITION.
- IMPACT TEST EXEMPT AS PER TABLE 323.2.2A.
- WELD PROCEDURE: WPS-1/LT-8
- COMMERCIAL SANDBLAST TO SSPC SP7.
- PAINT: ONE COAT PRIMER AND TWO COATS WARM GREY ENAMEL ON EXPOSED SURFACES.
- INSULATION: NONE
- PLUG ALL OPENINGS FOR SHIPMENT.
- APPROX. WT.: 3600 lbs
- QTY. 1 REQUIRED.

ENERGERA

PO# 23258

SO# 231054

THIS DRAWING IS THE PROPERTY OF FOURSTAR RESOURCES INC. AND IS NOT TO BE PRINTED, PHOTOGRAPHED, COPIED, LOANED OR USED WITHOUT ITS PERMISSION

	COIL #1 6-TUBES PREHEAT	COIL #2 4-TUBES REHEAT	
M.A.W.P. @ 300°F	3270 PSIG	3270 PSIG	
M.D.M.T.	-50°F	-50°F	
LTD. BY	FLANGES	FLANGES	
HYDROTEST	4905 PSIG	4905 PSIG	
C.A.	0.0625"	0.0625"	
RADIOGRAPHY	10%	10%	
HEATING SURFACE	99 sq ft	66 sq ft	
VOLUME	9.2 cu ft	6.2 cu ft	
CRN	T2005.2	T2005.2	
PWHT		NONE	

0	ISSUED FOR CONSTRUCTION	WT	WT	AUG23/23
B	RE-ISSUED FOR APPROVAL	WT	WT	AUG02/23
REV.	DESCRIPTION	BY	CHK'D	DATE

FSR
INCFOURSTAR RESOURCES INC.
NISKU, ALBERTA, CANADA

DRAWN BY:	DATE	CHECKED BY:	DATE
WT	JUL07/23	WT	JUL07/23
APPROVED BY:	DATE	SCALE:	
WT	JUL07/23	3/4" = 1'-0"	

4"-(10) TUBE 3270 PSIG
DUAL PASS COIL FOR FSR
MODEL 750IH INDIRECT HEATERDRAWING NO.
231054COIL-LH02

AS BUILT