
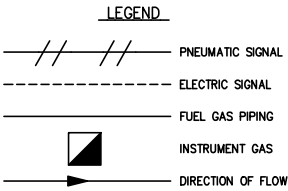


CLIENT
FOURSTAR RESOURCES INC.

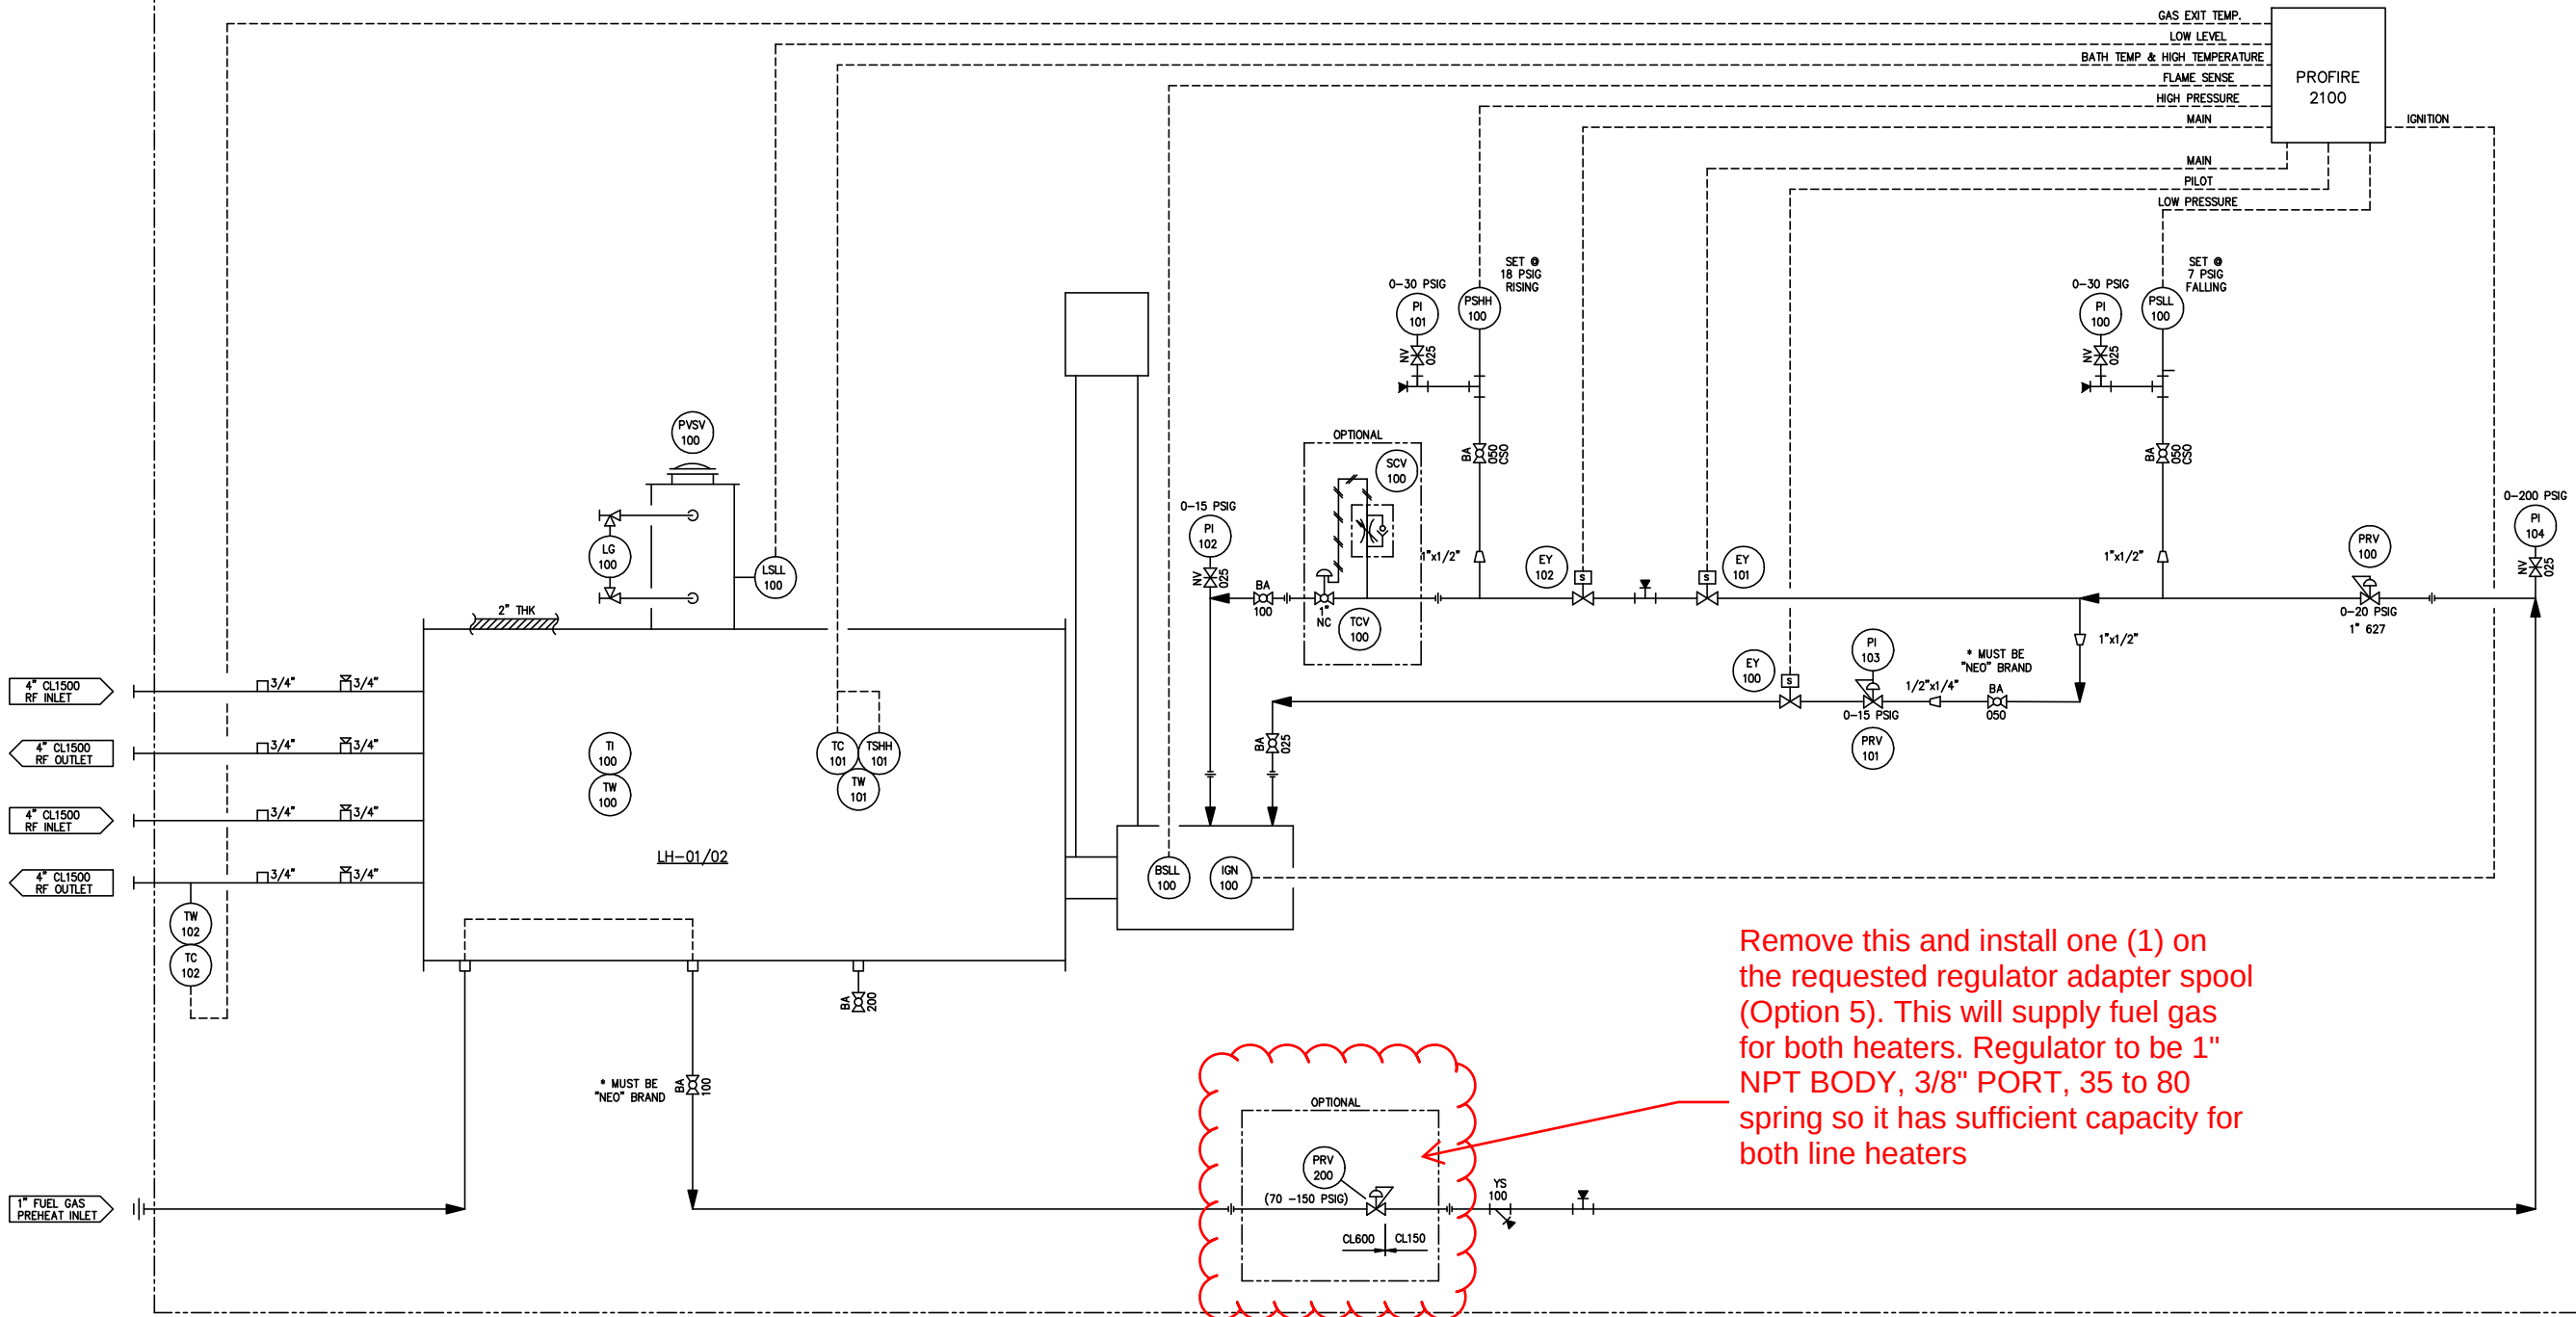

LH-01/02

MODEL: 750 IH (LEFT HAND MOUNT)

SIZE: 36" OD x 14'-0" LG

COIL: PREHEAT 4" 6-TUBE/REHEAT 4" 4-TUBE

M.A.W.P.: 3270 PSIG

DESIGN TEMP.: 300°F

M.D.M.T.: -50°F

C.A.: 1/16"

RADIOGRAPHY: 10%

- GENERAL NOTES:
- ALL NPT FITTINGS TO BE CL 2000 OR 3000 SA-105N
 - ALL PIPE AND NIPPLES TO BE SCH 80 SA-106B

ralrahman 2023-08-15 11:53:33 AM **Approved**

Rizwan Al Rahman - Sr. Engineer

Digitally signed by Rizwan Al Rahman - Sr. Engineer
DN: C=CA, E=ralrahman@energera.com, O=ENH, OU=ENH,
CN=Rizwan Al Rahman - Sr. Engineer
Date: 2022.11.08 09:41:40-0700

REV.	DESCRIPTION	BY	CHK'D	DATE
C	RE-ISSUED FOR APPROVAL	WT	WT	AUG4/23

ENERGERA		PO# 23258	SO# 231054
THIS DRAWING IS THE PROPERTY OF FOURSTAR RESOURCES INC. AND IS NOT TO BE PRINTED, PHOTOGRAPHED, COPIED, LOANED OR USED WITHOUT ITS PERMISSION			
FSR INC		FOURSTAR RESOURCES INC. NISKU, ALBERTA, CANADA	P&ID FOR FSR INDIRECT HEATER w/ PROFIRE 2100
DRAWN BY: MN	DATE: MAY27/18	CHECKED BY: WT	DATE: MAY27/18
APPROVED BY: WT	DATE: MAY27/18	SCALE: NTS	DRAWING NO. 231054PID-LH01/02