




NOTES
1. THIS P&ID IS ONLY FOR LINEHEATER LH-01. LH-02 IS IDENTICAL TO LH-01, EXCEPT LH-02 DOES NOT HAVE THE RESTRICTIVE ORIFICE ON THE OUTLET

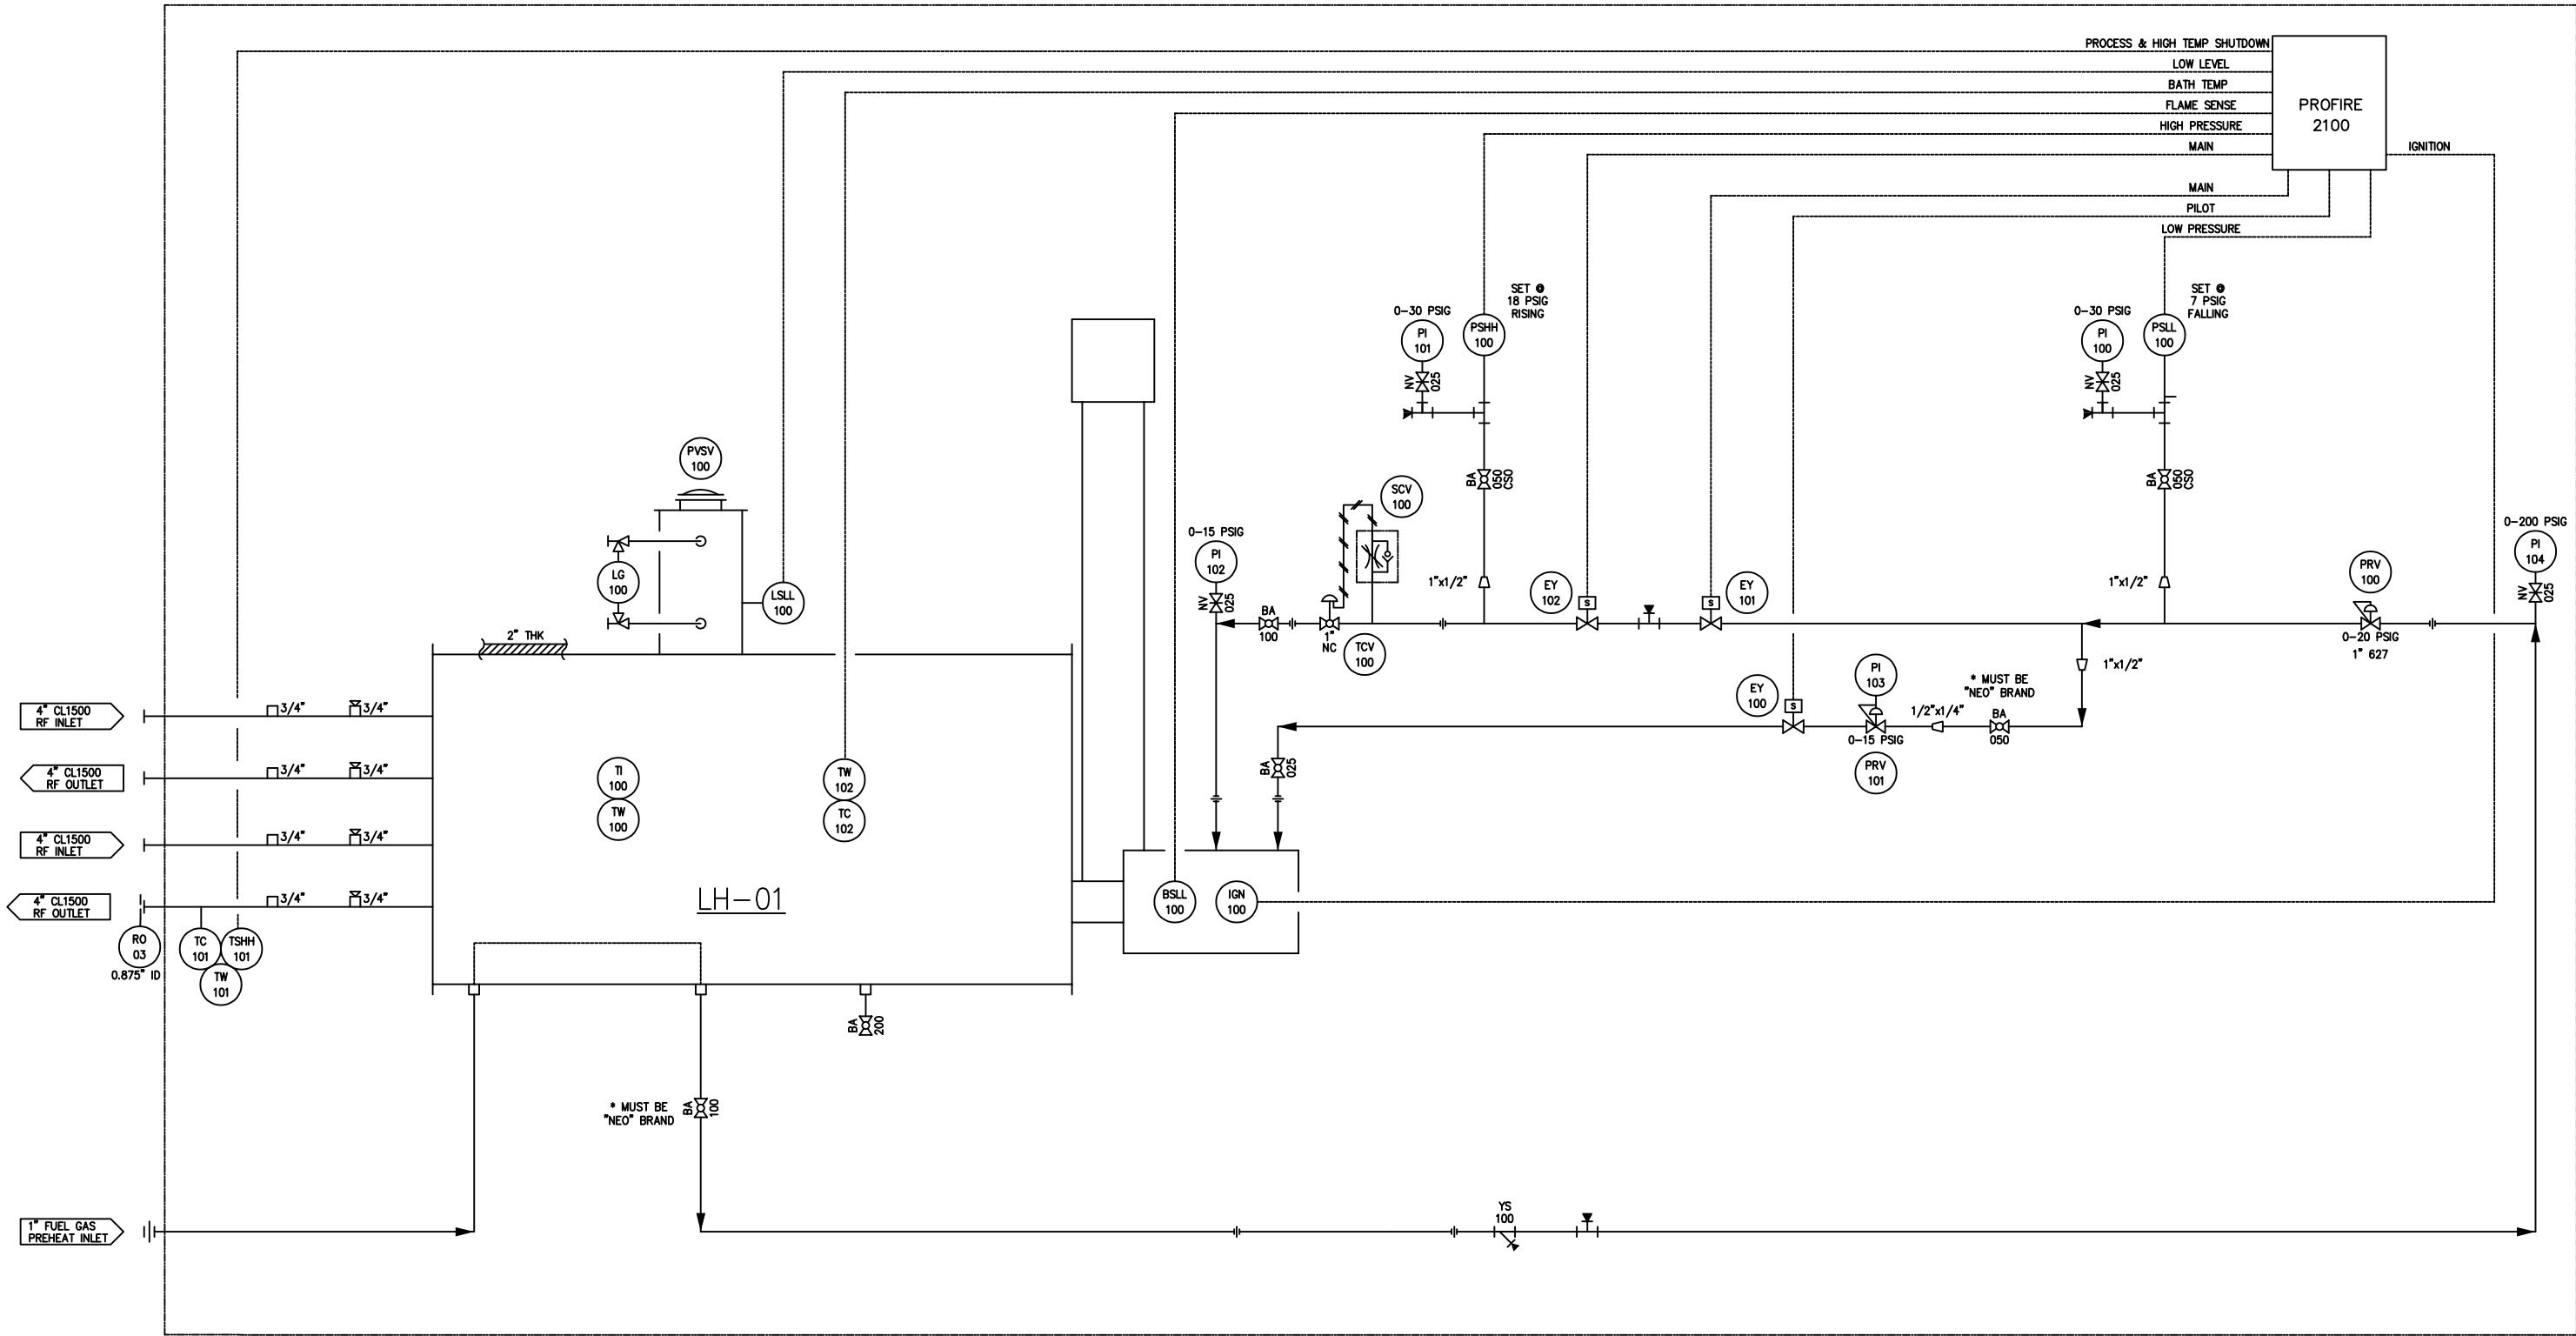

IN-LINE HEATER
750,000 BTU/HR
LH-01

ENERGERA
LH-01 INDIRECT FIRED HEATER

PROCESS AND INSTRUMENTATION DIAGRAM					
				DATE	DEC 06, 2023
				R.A.	SCALE N.T.S.
1	ISSUED FOR IMPLEMENTATION	R.A.	12/06/2023	CHECKED	D.N.
NO	REVISION	BY	DATE	APPROVED	R.A.

DWG NO CVX-PID-LH-01
SH NO 1 REV 1